

Seal:

**Consultants:**  
CIVIL ENGINEER:  
Meridian Engineering, LLC  
LANDSCAPE ARCHITECT:  
Craig Reynolds, RLA


**Submissions:**  
July 28, 2011 - Initial Meeting at  
August 18, 2011 - Public Meeting at  
September 30, 2011 - HMC, Tom  
Crombino, DDC and Thomas  
Johnson  
January 4, 2012 - TRF Application  
January 14, 2012 - Revised Station  
January 27, 2012 - Revised Station  
Panel Submissions  
June 5, 2012 - Civil Plans, Sections  
July 26, 2012 - Civil Plans, Sections  
August 14, 2012 - HMC Construction  
Documents

**NELSON ENGLISH / WILLIE WARD**  
**PARK ENHANCEMENT PROJECT**  
**CITY OF KEY WEST**  
300 Catherine Street, Key West, Florida 33040

FLOTTED: 8/19/2012 12:31 PM  
Drawing Size | Project #:  
24x36 | MK-11035  
Drawn By: | Checked By:  
AAG | ADS  
Title: |  
**HARDSCAPE**  
**NOTES AND LEGENDS**

Sheet Number:  
**A1.2.0**  
Date: August 17, 2012  
©2012 by mbl | k2m Architecture, Inc.

**ZONE DESIGNATIONS**

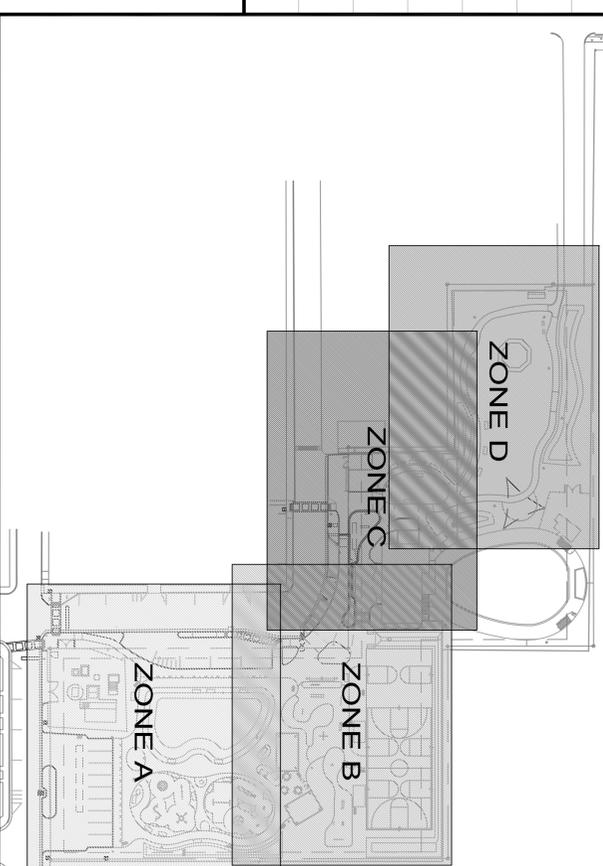

**LEGEND**

SYMBOL	DESCRIPTION
	RAMP OR SLOPE
	SECTION MARKER
	ELEVATION MARKER
	ARC CENTER POINT
	ARC ENDPOINT
	ORIGIN
	EDGE OF MATERIAL



**PAVING SCHEDULE**

SYMBOL	MATERIAL	DESCRIPTION
	FLEXIBLE PAVING COLOR A	MANUFACTURER: KBI FLX-PAVE PRODUCT TYPE: P2000 PRODUCT COLOR: CYPRESS
	FLEXIBLE PAVING COLOR B	MANUFACTURER: KBI FLX-PAVE PRODUCT TYPE: P2000 PRODUCT COLOR: GREEN
	FLEXIBLE PAVING COLOR C	MANUFACTURER: KBI FLX-PAVE PRODUCT TYPE: P2000 PRODUCT COLOR: ADA BLUE
	FLEXIBLE PAVING COLOR D	MANUFACTURER: KBI FLX-PAVE PRODUCT TYPE: P2000 PRODUCT COLOR: RED
	FLEXIBLE PAVING COLOR E	MANUFACTURER: KBI FLX-PAVE PRODUCT TYPE: P2000 PRODUCT COLOR: ADA DARK BROWN
	ASPHALT PAVEMENT	2.5" TYPE SP-12.5 ASPHALT PER DOT SPECIFICATIONS
	CONCRETE	4" CONCRETE COLOR: NATURAL GRAY FINISH: LIGHT BROOM AND ROCK SALT. ROCK SALT NOT TO EXCEED 1/4" DIAMETER.
	DARK CONCRETE PAVER	4" X 8" X 3/4" CONCRETE PAVES, COLOR: DARK SANTA FE BY TREARON GROUP 45 DEGREE HERRINGBONE
	LIGHT CONCRETE PAVER	4" X 8" X 3/4" CONCRETE PAVES, COLOR: LIGHT CAPPACCINO B7 TREARON GROUP 45 DEGREE HERRINGBONE
	WHITE CONCRETE PAVES	4" X 8" X 3/4" CONCRETE PAVES, COLOR: WHITE BY TREARON GROUP
	BLUE CONCRETE PAVES	4" X 8" X 3/4" CONCRETE PAVES, COLOR: BLUE BY TREARON GROUP
	DARK CONCRETE PAVES DETECTABLE WARNING	4" X 8" X 3/4" CONCRETE PAVES- COLOR: DARK CONCRETE PAVES- SANTA FE BY TREARON GROUP TRUNCATED DOME FOR TACTILE SURFACE AT PEDESTRIAN INTERSECTION.

01  
**FLEXI-PAVE COLORS**  
SCALE: NTS



Seal:


**Consultants:**  
 CIVIL ENGINEER:  
 Meridian Engineering, LLC  
 LANDSCAPE ARCHITECT:  
 Craig Reynolds, RLA

**Submissions:**  
 July 28, 2011 - Initial Submittal at:  
 August 18, 2011 - Public Meeting at:  
 September 30, 2011 - HMC's Team  
 Presentation, HMC and Meridian  
 January 4, 2012 - Final Application  
 January 14, 2012 - Revised Submittal  
 January 27, 2012 - Revised Submittal  
 June 5, 2012 - Civil/Structural Submittals  
 June 5, 2012 - Civil/Structural Submittals  
 July 17, 2012 - 100% Construction  
 Drawings

**NELSON ENGLISH / WILLIE WARD  
 PARK ENHANCEMENT PROJECT**  
**CITY OF KEY WEST**  
 300 Catherine Street, Key West, Florida 33040

PLOTTED: 8/19/2012 12:35 PM  
 Drawing Size: Project #:  
 24x36: MK-11035  
 Drawn By: Checked By:  
 AAG AOS  
**Title:**  
**HARDSCAPE PLAN**  
**ZONE B**

Sheet Number:  
**A1.2.2**  
 Date: August 17, 2012  
 ©2012 by mbi | k2m Architecture, Inc.

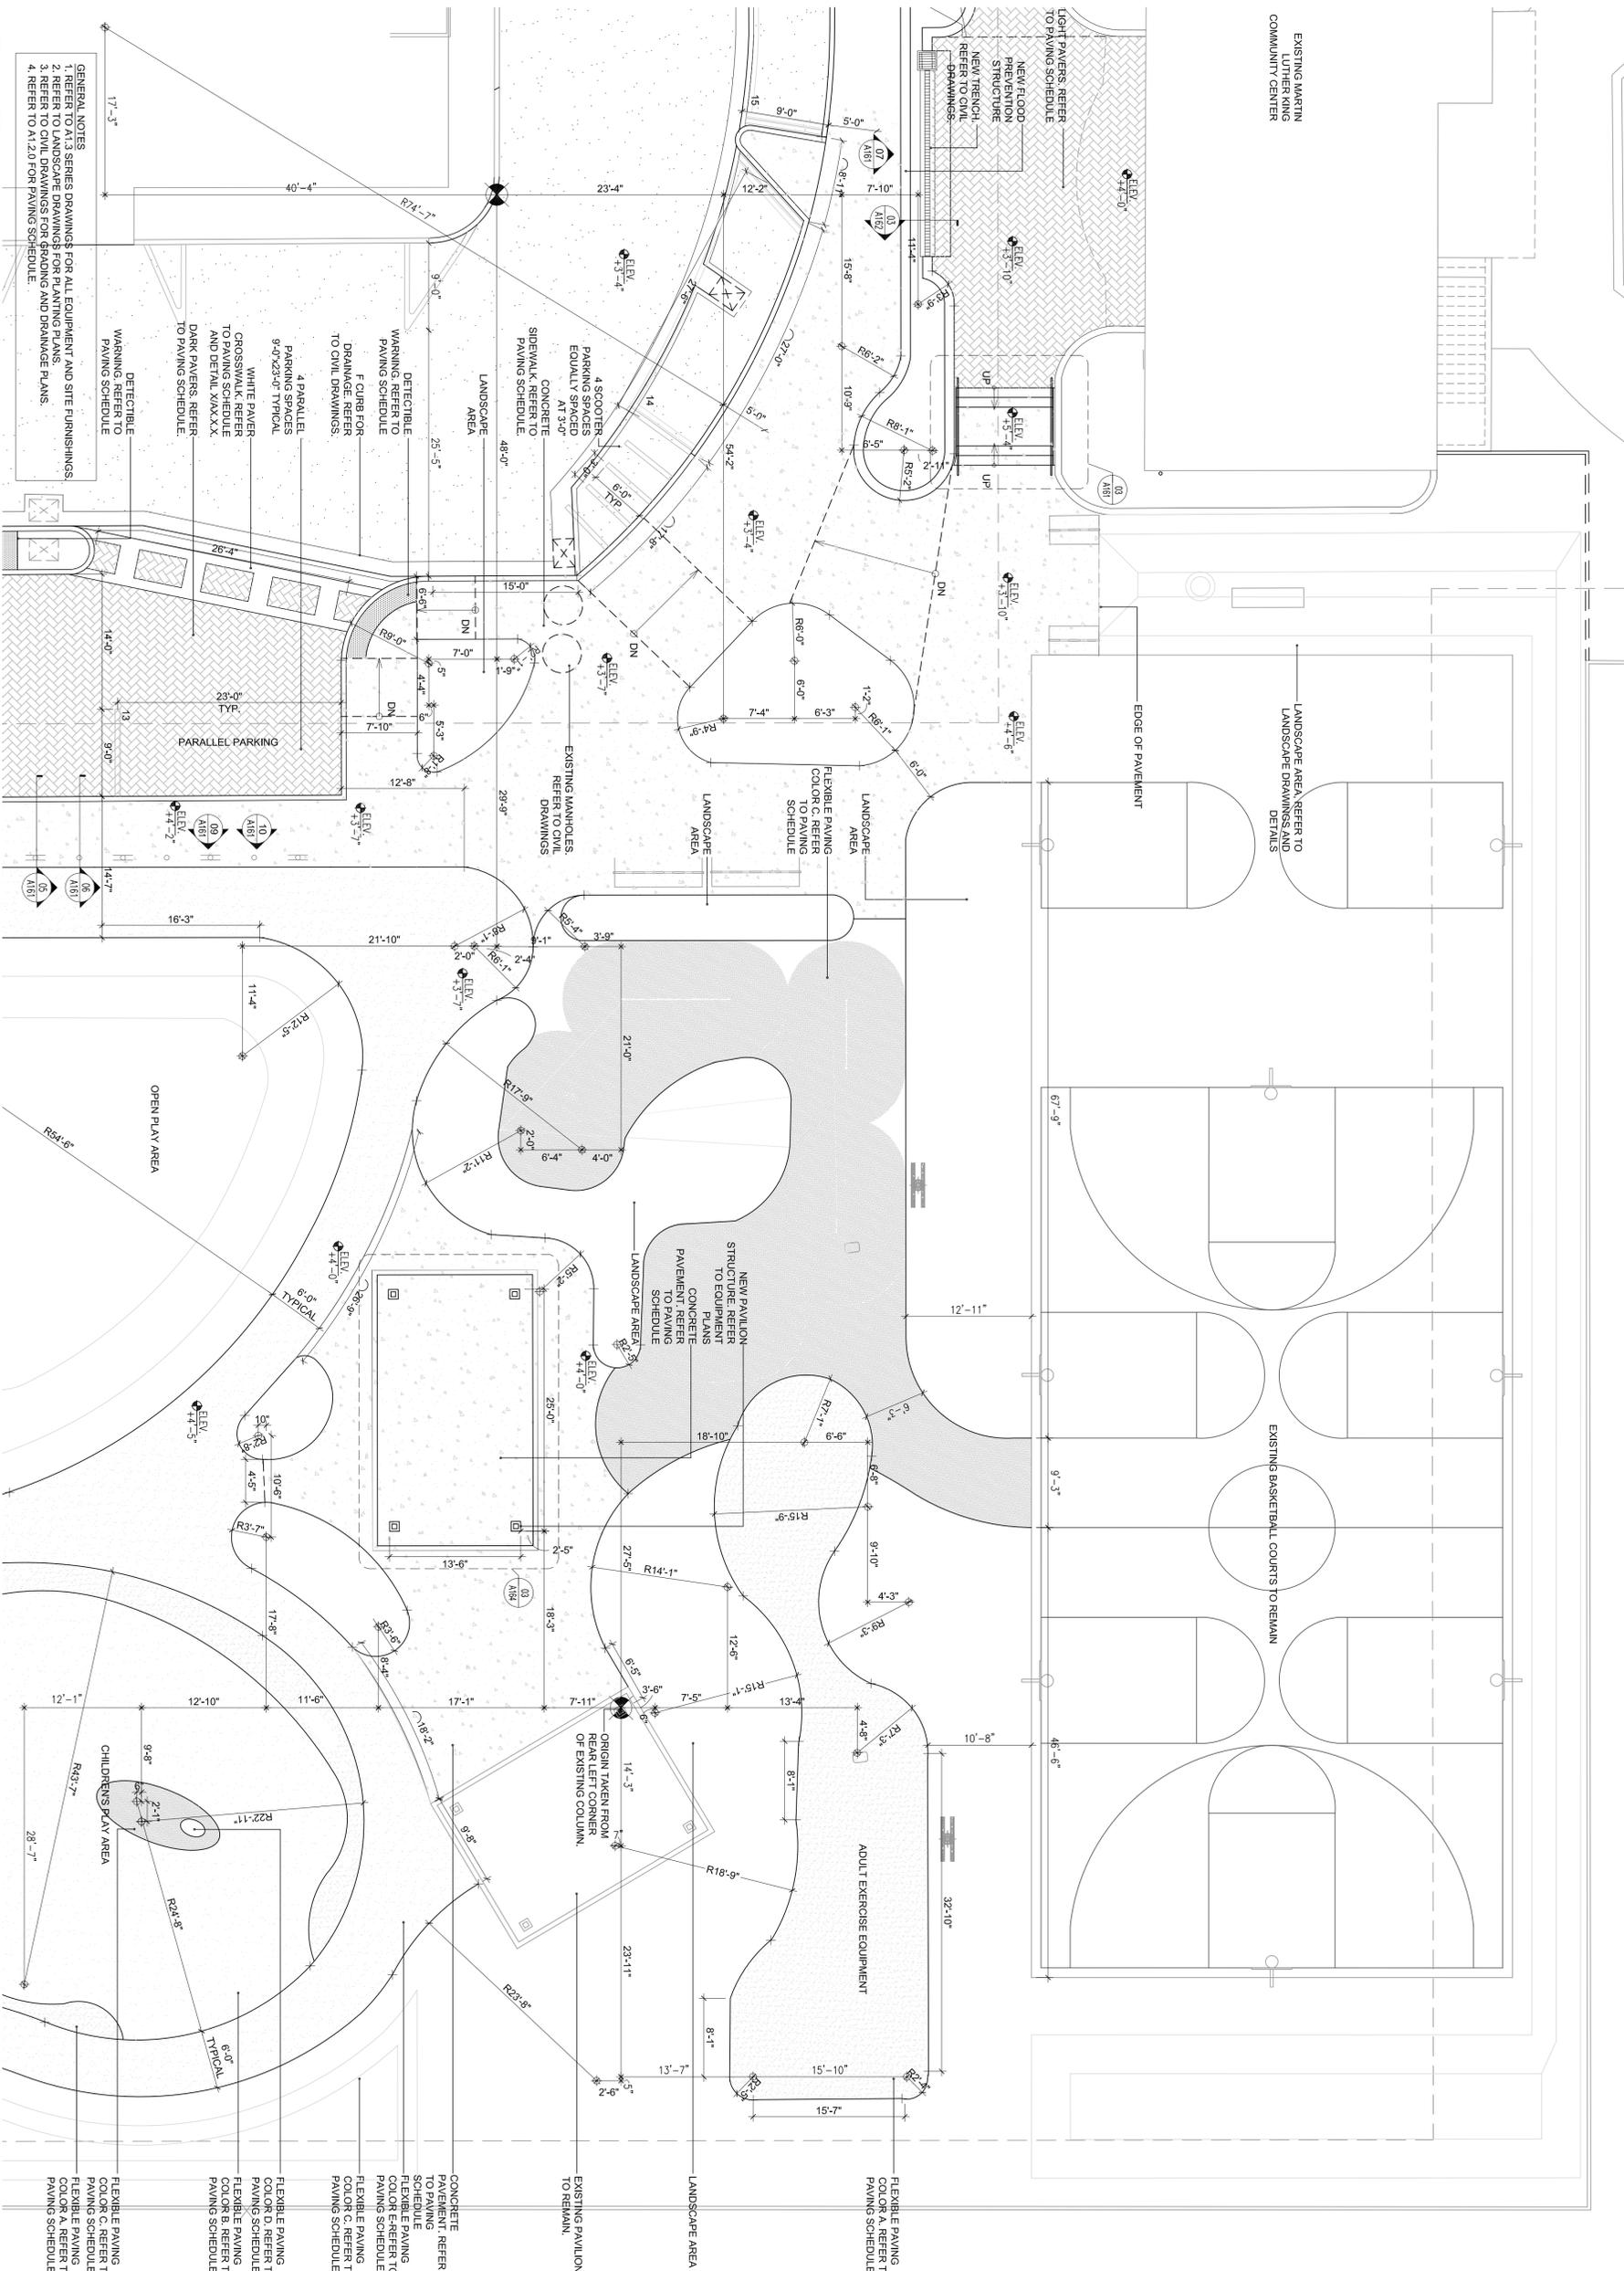


**GENERAL NOTES**  
 1. REFER TO A1.3 SERIES DRAWINGS FOR ALL EQUIPMENT AND SITE FURNISHINGS.  
 2. REFER TO LANDSCAPE DRAWINGS FOR PLANTING PLANS.  
 3. REFER TO CIVIL DRAWINGS FOR GRADING AND DRAINAGE PLANS.  
 4. REFER TO A1.20 FOR PAVING SCHEDULE.

01 **HARDSCAPE PLAN - ZONE B**  
 SCALE: 1/8" = 1'-0"




 
- GENERAL NOTES**
1. REFER TO A1.3 SERIES DRAWINGS FOR ALL EQUIPMENT AND SITE FURNISHINGS.
  2. REFER TO LANDSCAPE DRAWINGS FOR PLANTING PLANS.
  3. REFER TO CIVIL DRAWINGS FOR GRADING AND DRAINAGE PLANS.
  4. REFER TO A1.2.0 FOR PAVING SCHEDULE.



01  
A1.2.3

**HARDSCAPE PLAN - ZONE C**

 SCALE: 1/8"=1'-0"

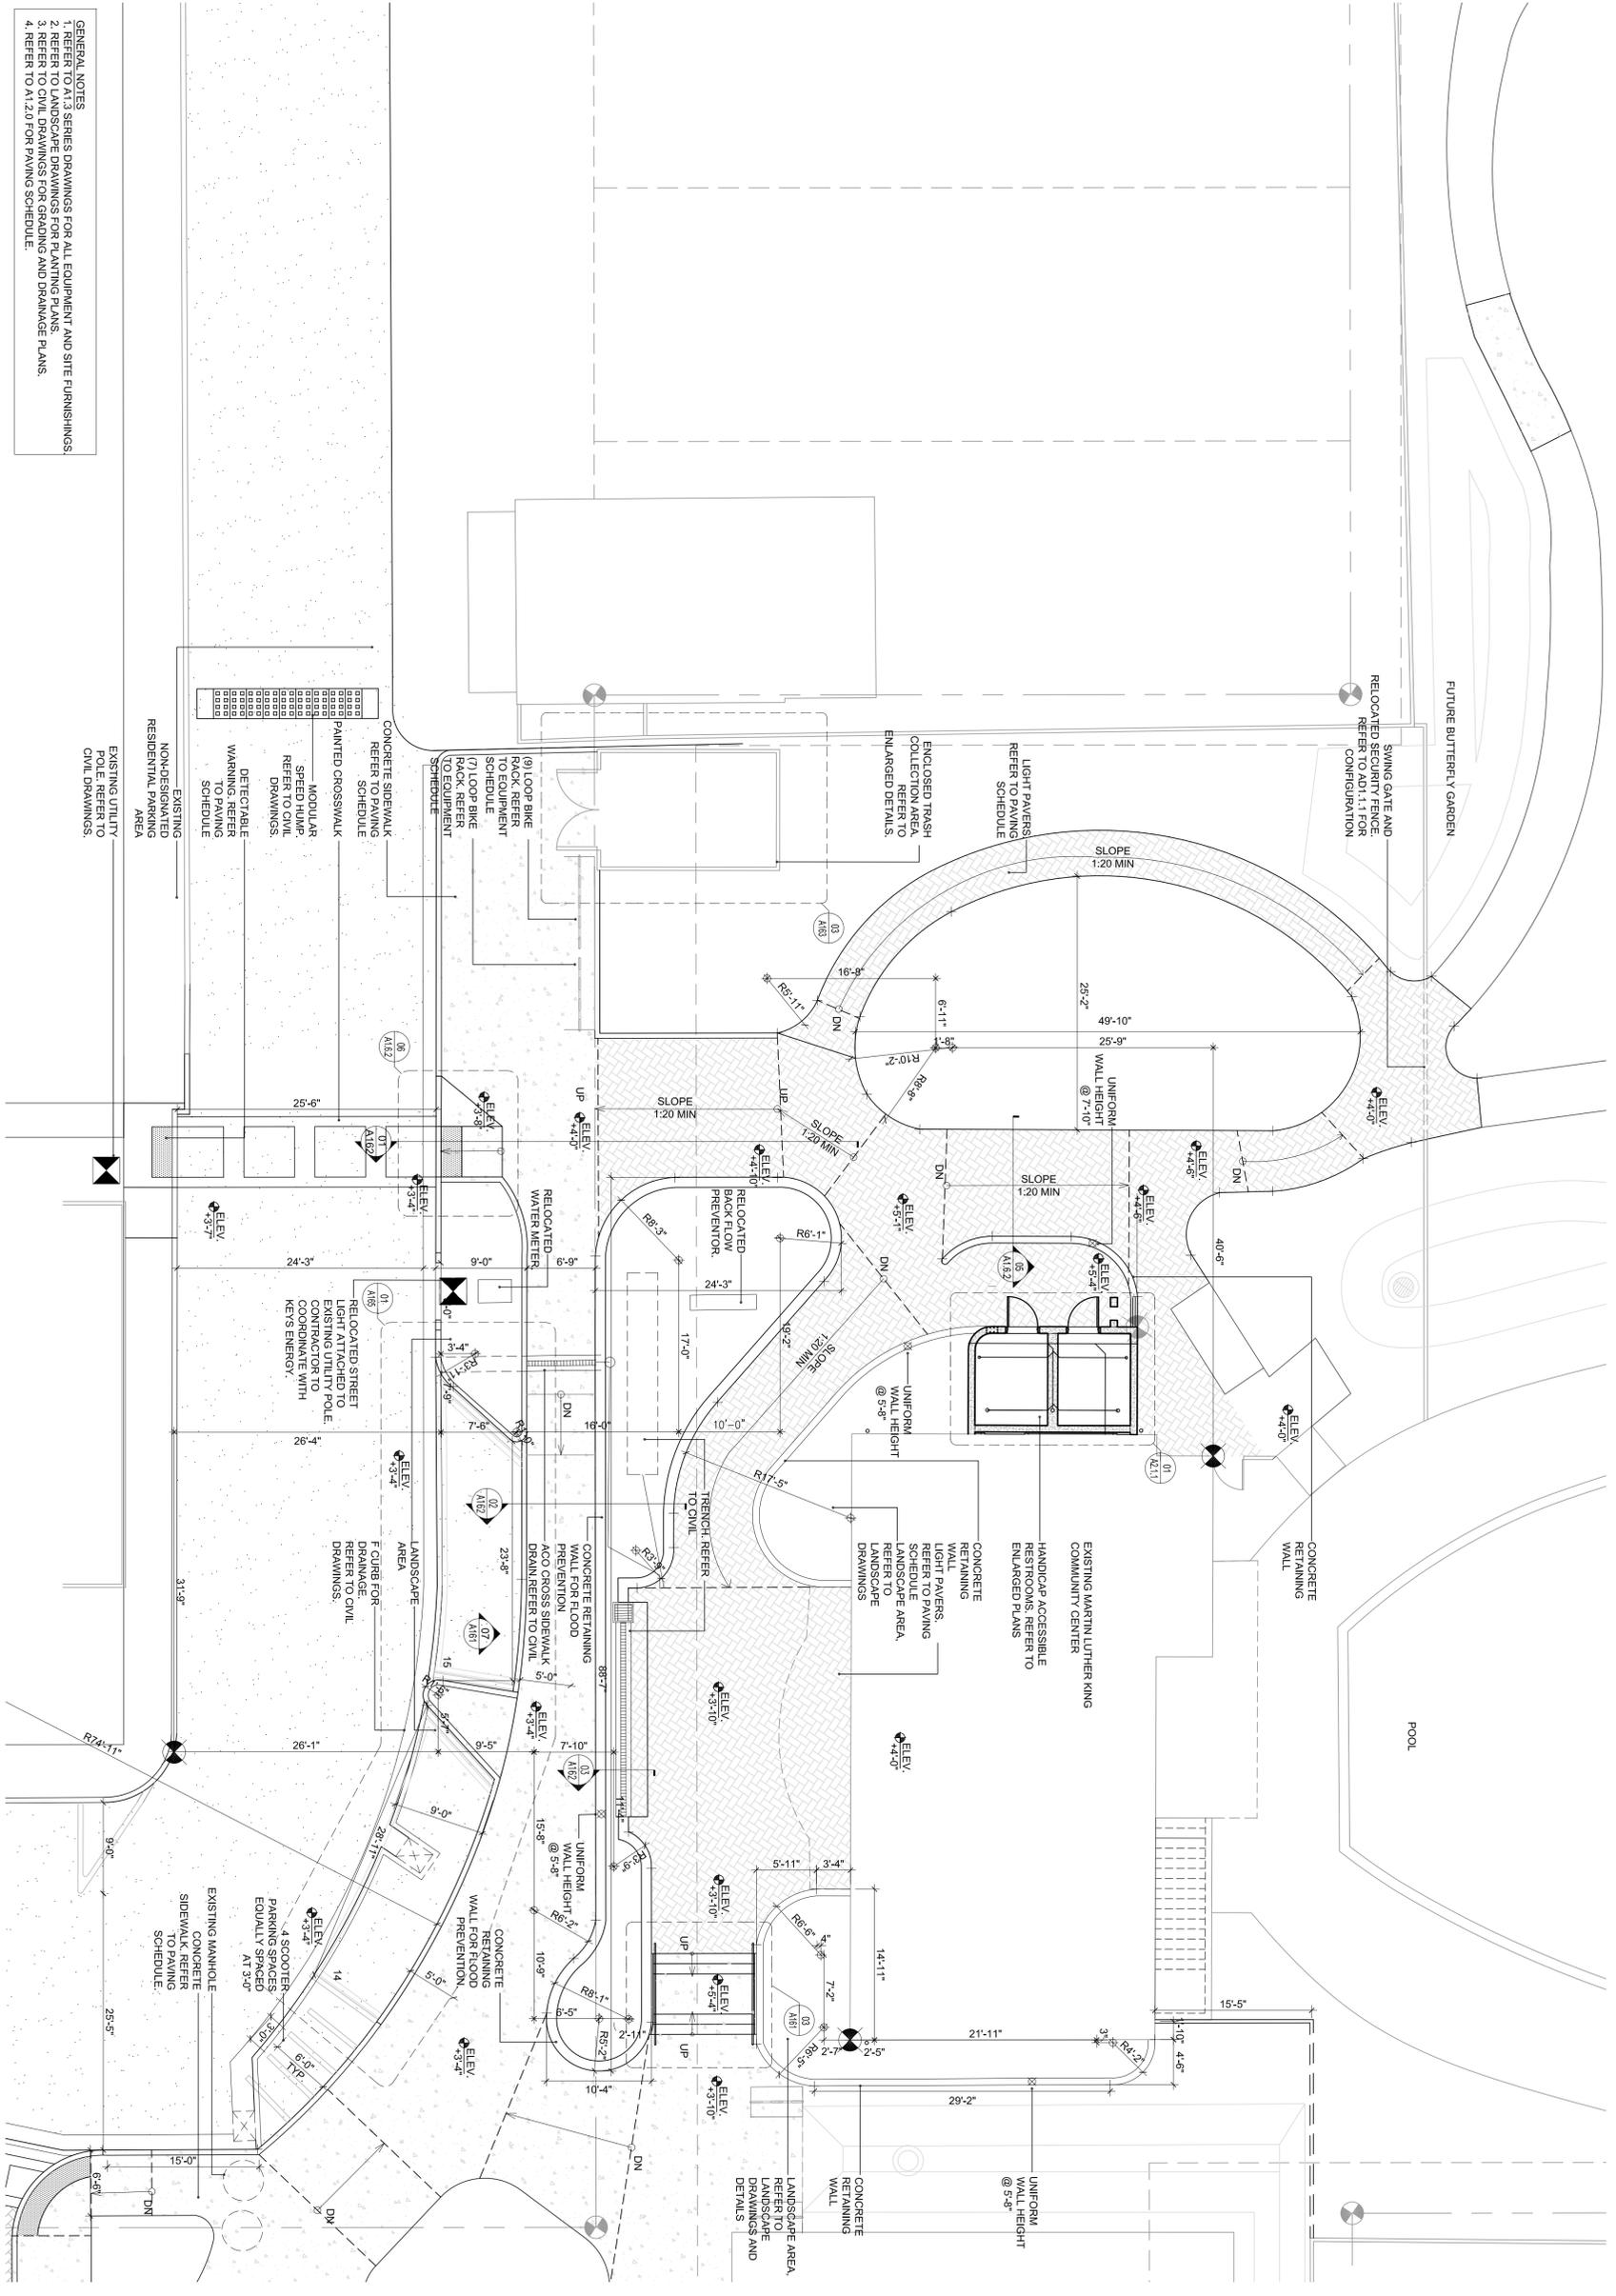

**ARCHITECT:**  
mbi | k2m  
ARCHITECTURE, INC.  
Architecture, Interior Design,  
Procurement,  
Owner Representation,  
Specialty Consulting

1001 Whitehead Street  
Key West, Florida 34240  
Tel: 305.292.7722  
Fax: 305.292.2182  
Email: info@mbi-k2m.com  
www.mbi-k2m.com  
PROJ. REG. AA26001069  
Building Relationships  
Based on Trust and Respect

Southwest Florida 1 Washington DC

**Consultants:**  
CIVIL ENGINEER:  
Meridian Engineering, LLC  
LANDSCAPE ARCHITECT:  
Craig Reynolds, RLA

**Submissions:**  
July 26, 2011 - Public Meeting at  
August 16, 2011 - Public Meeting at  
September 30, 2011 - HADC, Town  
Commission, City and Township  
January 4, 2012 - TRF Application  
January 14, 2012 - Revised Stationing  
January 27, 2012 - Revised Stationing  
February 2012 - Final Stationing  
June 5, 2012 - City Public Submittal  
July 26, 2012 - City Public Submittal  
August 17, 2012 - HADC Construction  
December 2012 - Construction  
Revisions

**NELSON ENGLISH / WILLIE WARD  
PARK ENHANCEMENT PROJECT**

**CITY OF KEY WEST**  
300 Catherine Street, Key West, Florida 33040

PLOTTED: 8/19/2012 12:37 PM  
Drawing Size: 24x36 Project #: MK-11035  
Drawn By: AOS  
Checked By: AOS

Title:  
**HARDSCAPE PLAN  
ZONE C**

Sheet Number:  
**A1.2.3**


Date: August 17, 2012  
©2012 by mbi | k2m Architecture, Inc.



01  
A1.2.4

**HARDSCAPE PLAN - ZONE D**  
SCALE: 1/8"=1'-0"

- GENERAL NOTES**
1. REFER TO A1.3 SERIES DRAWINGS FOR ALL EQUIPMENT AND SITE FURNISHINGS.
  2. REFER TO LANDSCAPE DRAWINGS FOR PLANTING PLANS.
  3. REFER TO CIVIL DRAWINGS FOR GRADING AND DRAINAGE PLANS.
  4. REFER TO A1.2.0 FOR FINISH SCHEDULE.

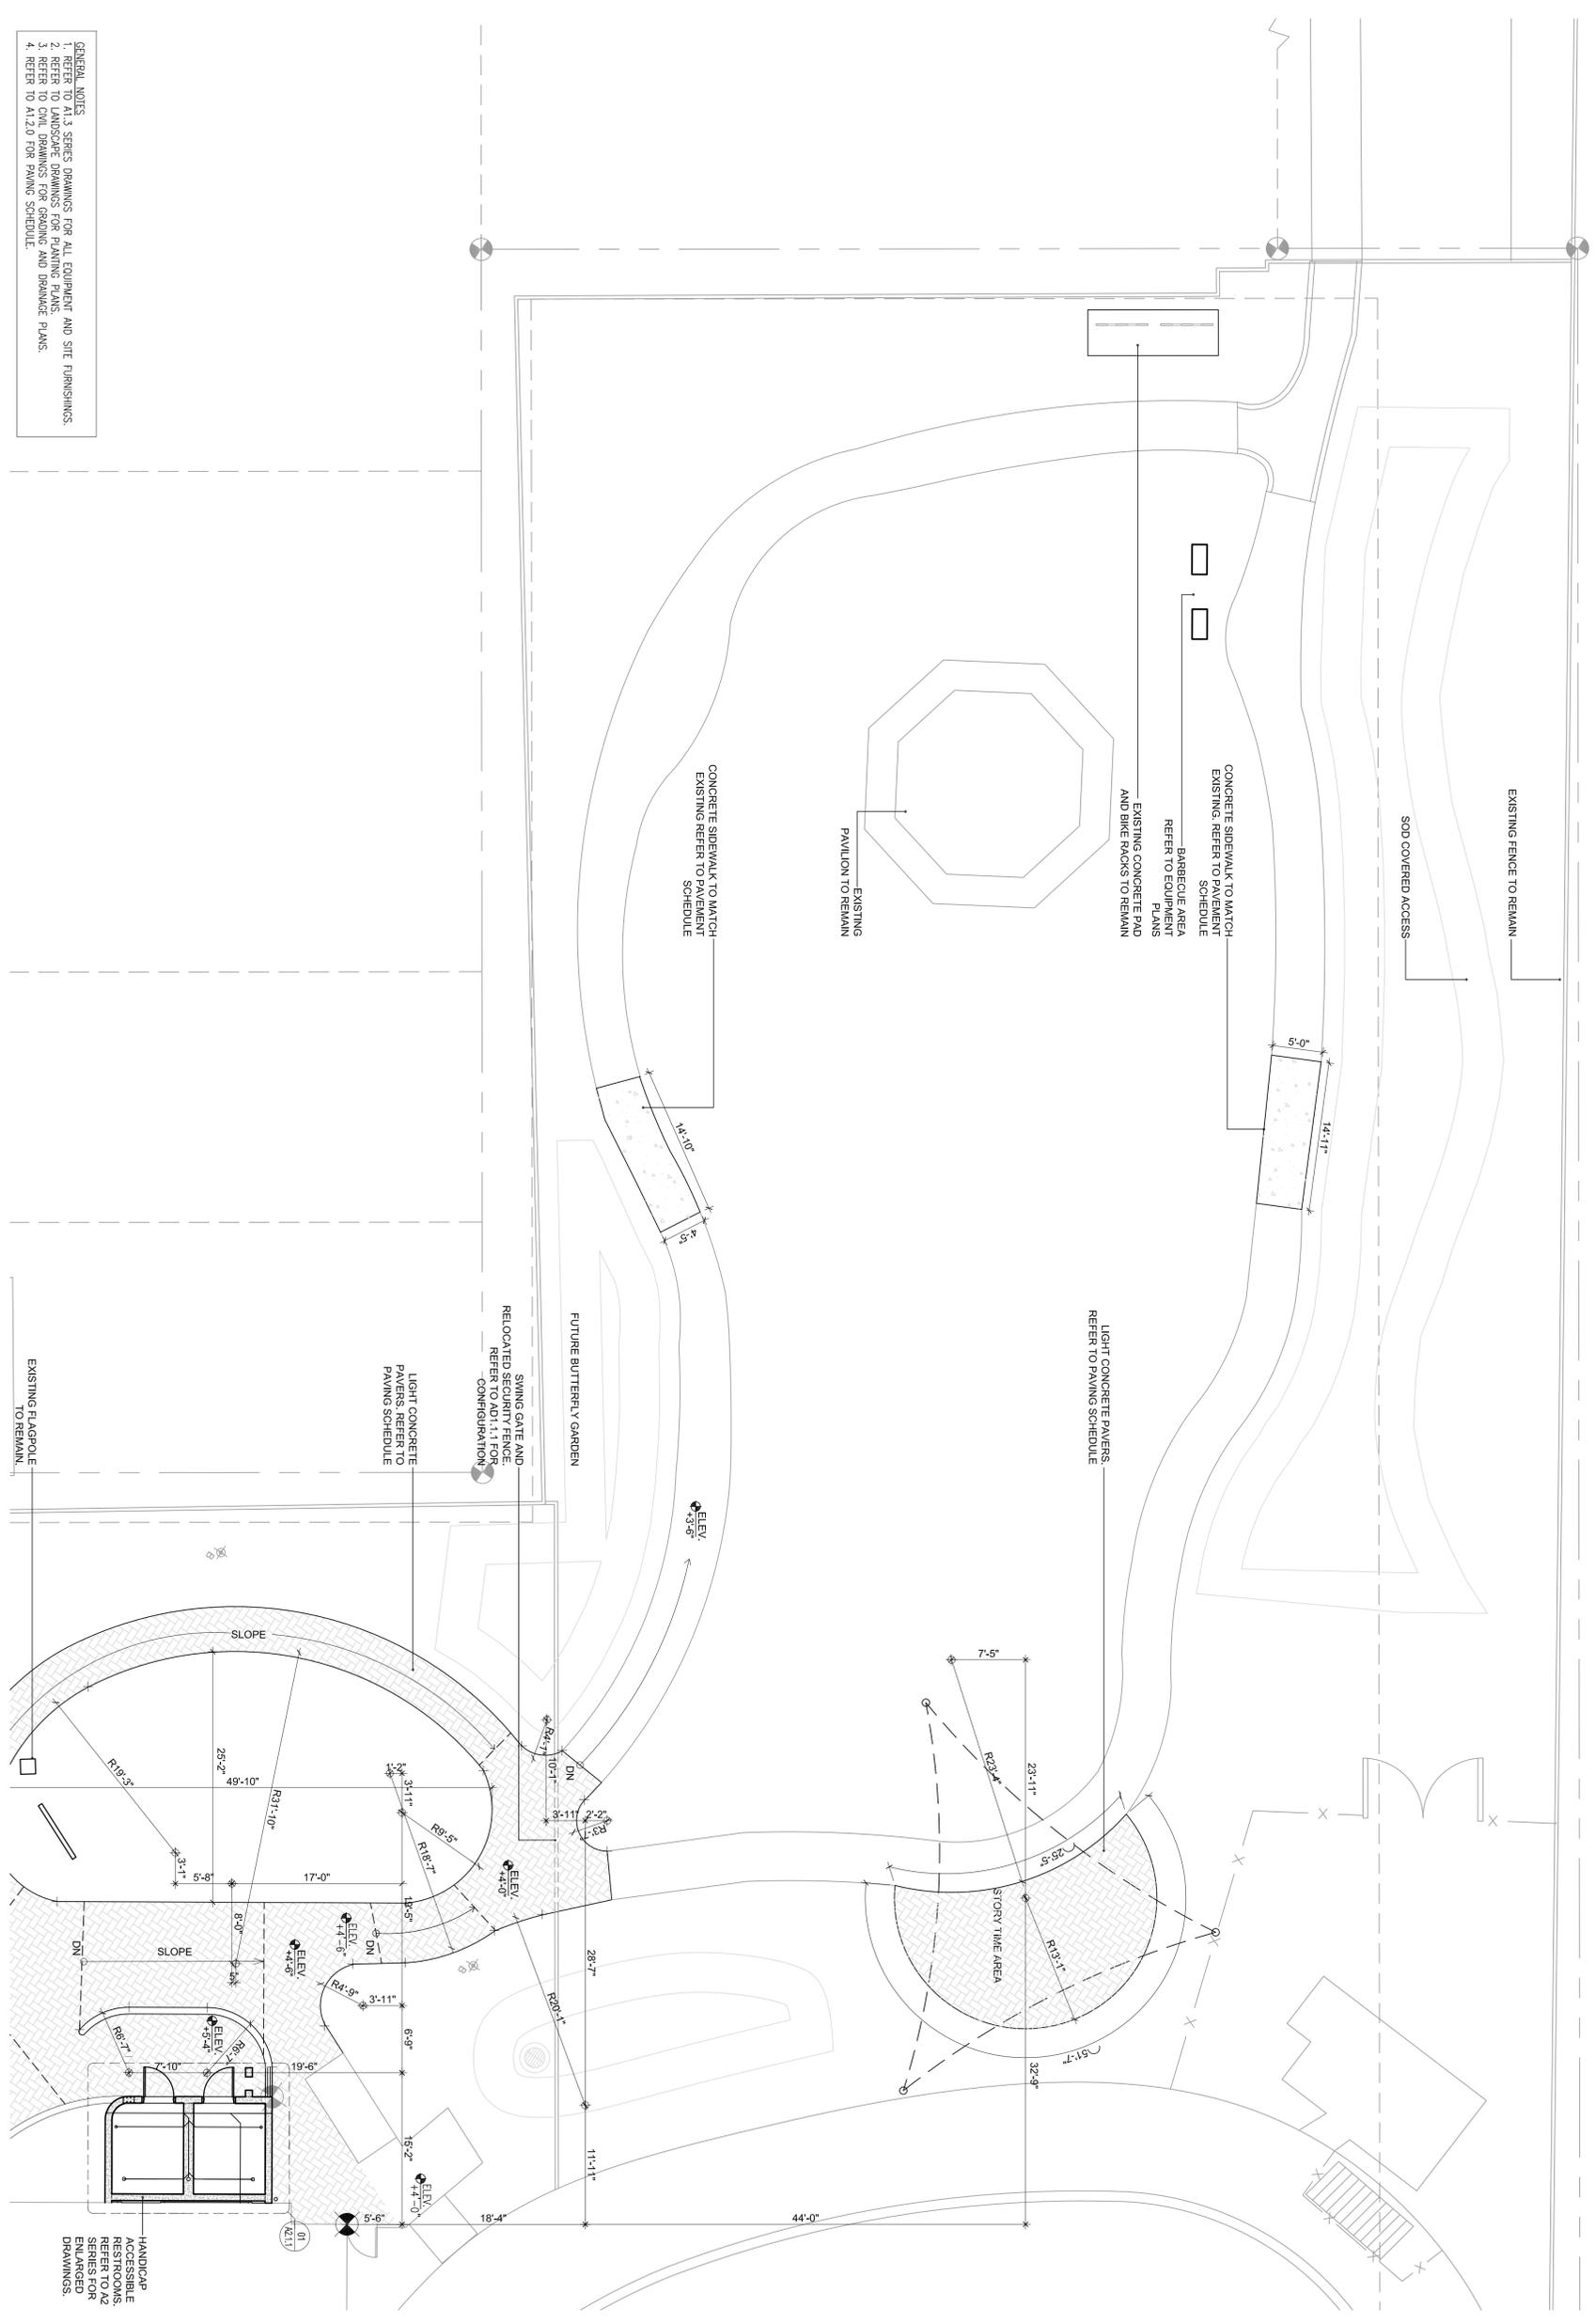

HANDICAP ACCESSIBLE RESTROOMS SERIES FOR ENLARGED DRAWINGS.

<p>Sheet Number: <b>A1.2.4</b></p> <p>Date: August 17, 2012</p> <p>©2012 by mbi   k2m Architecture, Inc.</p>	<p><b>NELSON ENGLISH / WILLIE WARD PARK ENHANCEMENT PROJECT</b></p> <p><b>CITY OF KEY WEST</b> 300 Catherine Street, Key West, Florida 33040</p>	<p><b>ARCHITECT:</b> mbi   k2m ARCHITECTURE, INC.</p> <p>Architecture, Interior Design, Procurement, Owner Representation, Specialty Consulting</p> <p>1001 Whitehead Street Key West, Florida 33040 Tel: 305.292.7722 Fax: 305.292.2182 Email: info@mbi-k2m.com www.mbi-k2m.com PROJ. REG. AA26001059 Building Registration Based on Truth and Honesty Southern Florida 1, Washington DC</p>	<p><b>CONSULTANTS:</b></p> <p>CIVIL ENGINEER: Merridian Engineering, LLC LANDSCAPE ARCHITECT: Craig Reynolds, RLA</p> <p><b>SUBMISSIONS:</b></p> <p>July 28, 2011 - Public Meeting at August 18, 2011 - Public Meeting at September 30, 2011 - HADC, Item October 10, 2011 - HADC, Item November 4, 2011 - TIF Application January 18, 2012 - Revised Submittal February 27, 2012 - Revised Submittal March 5, 2012 - City Public Hearing March 26, 2012 - City Public Hearing April 11, 2012 - HADC, Consideration April 11, 2012 - HADC, Consideration April 11, 2012 - HADC, Consideration</p>
--	--	---	---





Seal:


**Consultants:**  
CIVIL ENGINEER:  
Meridian Engineering, LLC  
LANDSCAPE ARCHITECT:  
Craig Reynolds, RLA

**Submissions:**  
July 28, 2011 - Public Meeting at  
August 18, 2011 - Public Meeting at  
September 30, 2011 - HMC, Town  
Commissioner, City and Towns  
January 4, 2012 - TRF Application  
January 14, 2012 - Revised Station  
January 27, 2012 - Revised Station  
April 5, 2012 - City Public Submittal  
April 23, 2012 - City Public Submittal  
April 23, 2012 - City Public Submittal  
April 23, 2012 - HMC Construction  
Documents

**NELSON ENGLISH / WILLIE WARD  
PARK ENHANCEMENT PROJECT**  
**CITY OF KEY WEST**  
300 Catherine Street, Key West, Florida 33040

PLOTTED: 8/19/2012 12:44 PM  
Drawing Size: 24x36 Project #: MK-11035  
Drawn By: AOS Checked By: AOS  
Title: **EQUIPMENT PLAN  
ZONE B**


Sheet Number:  
**A1.3.2**  
Date: August 17, 2012  
©2012 by mbi | k2m Architecture, Inc.

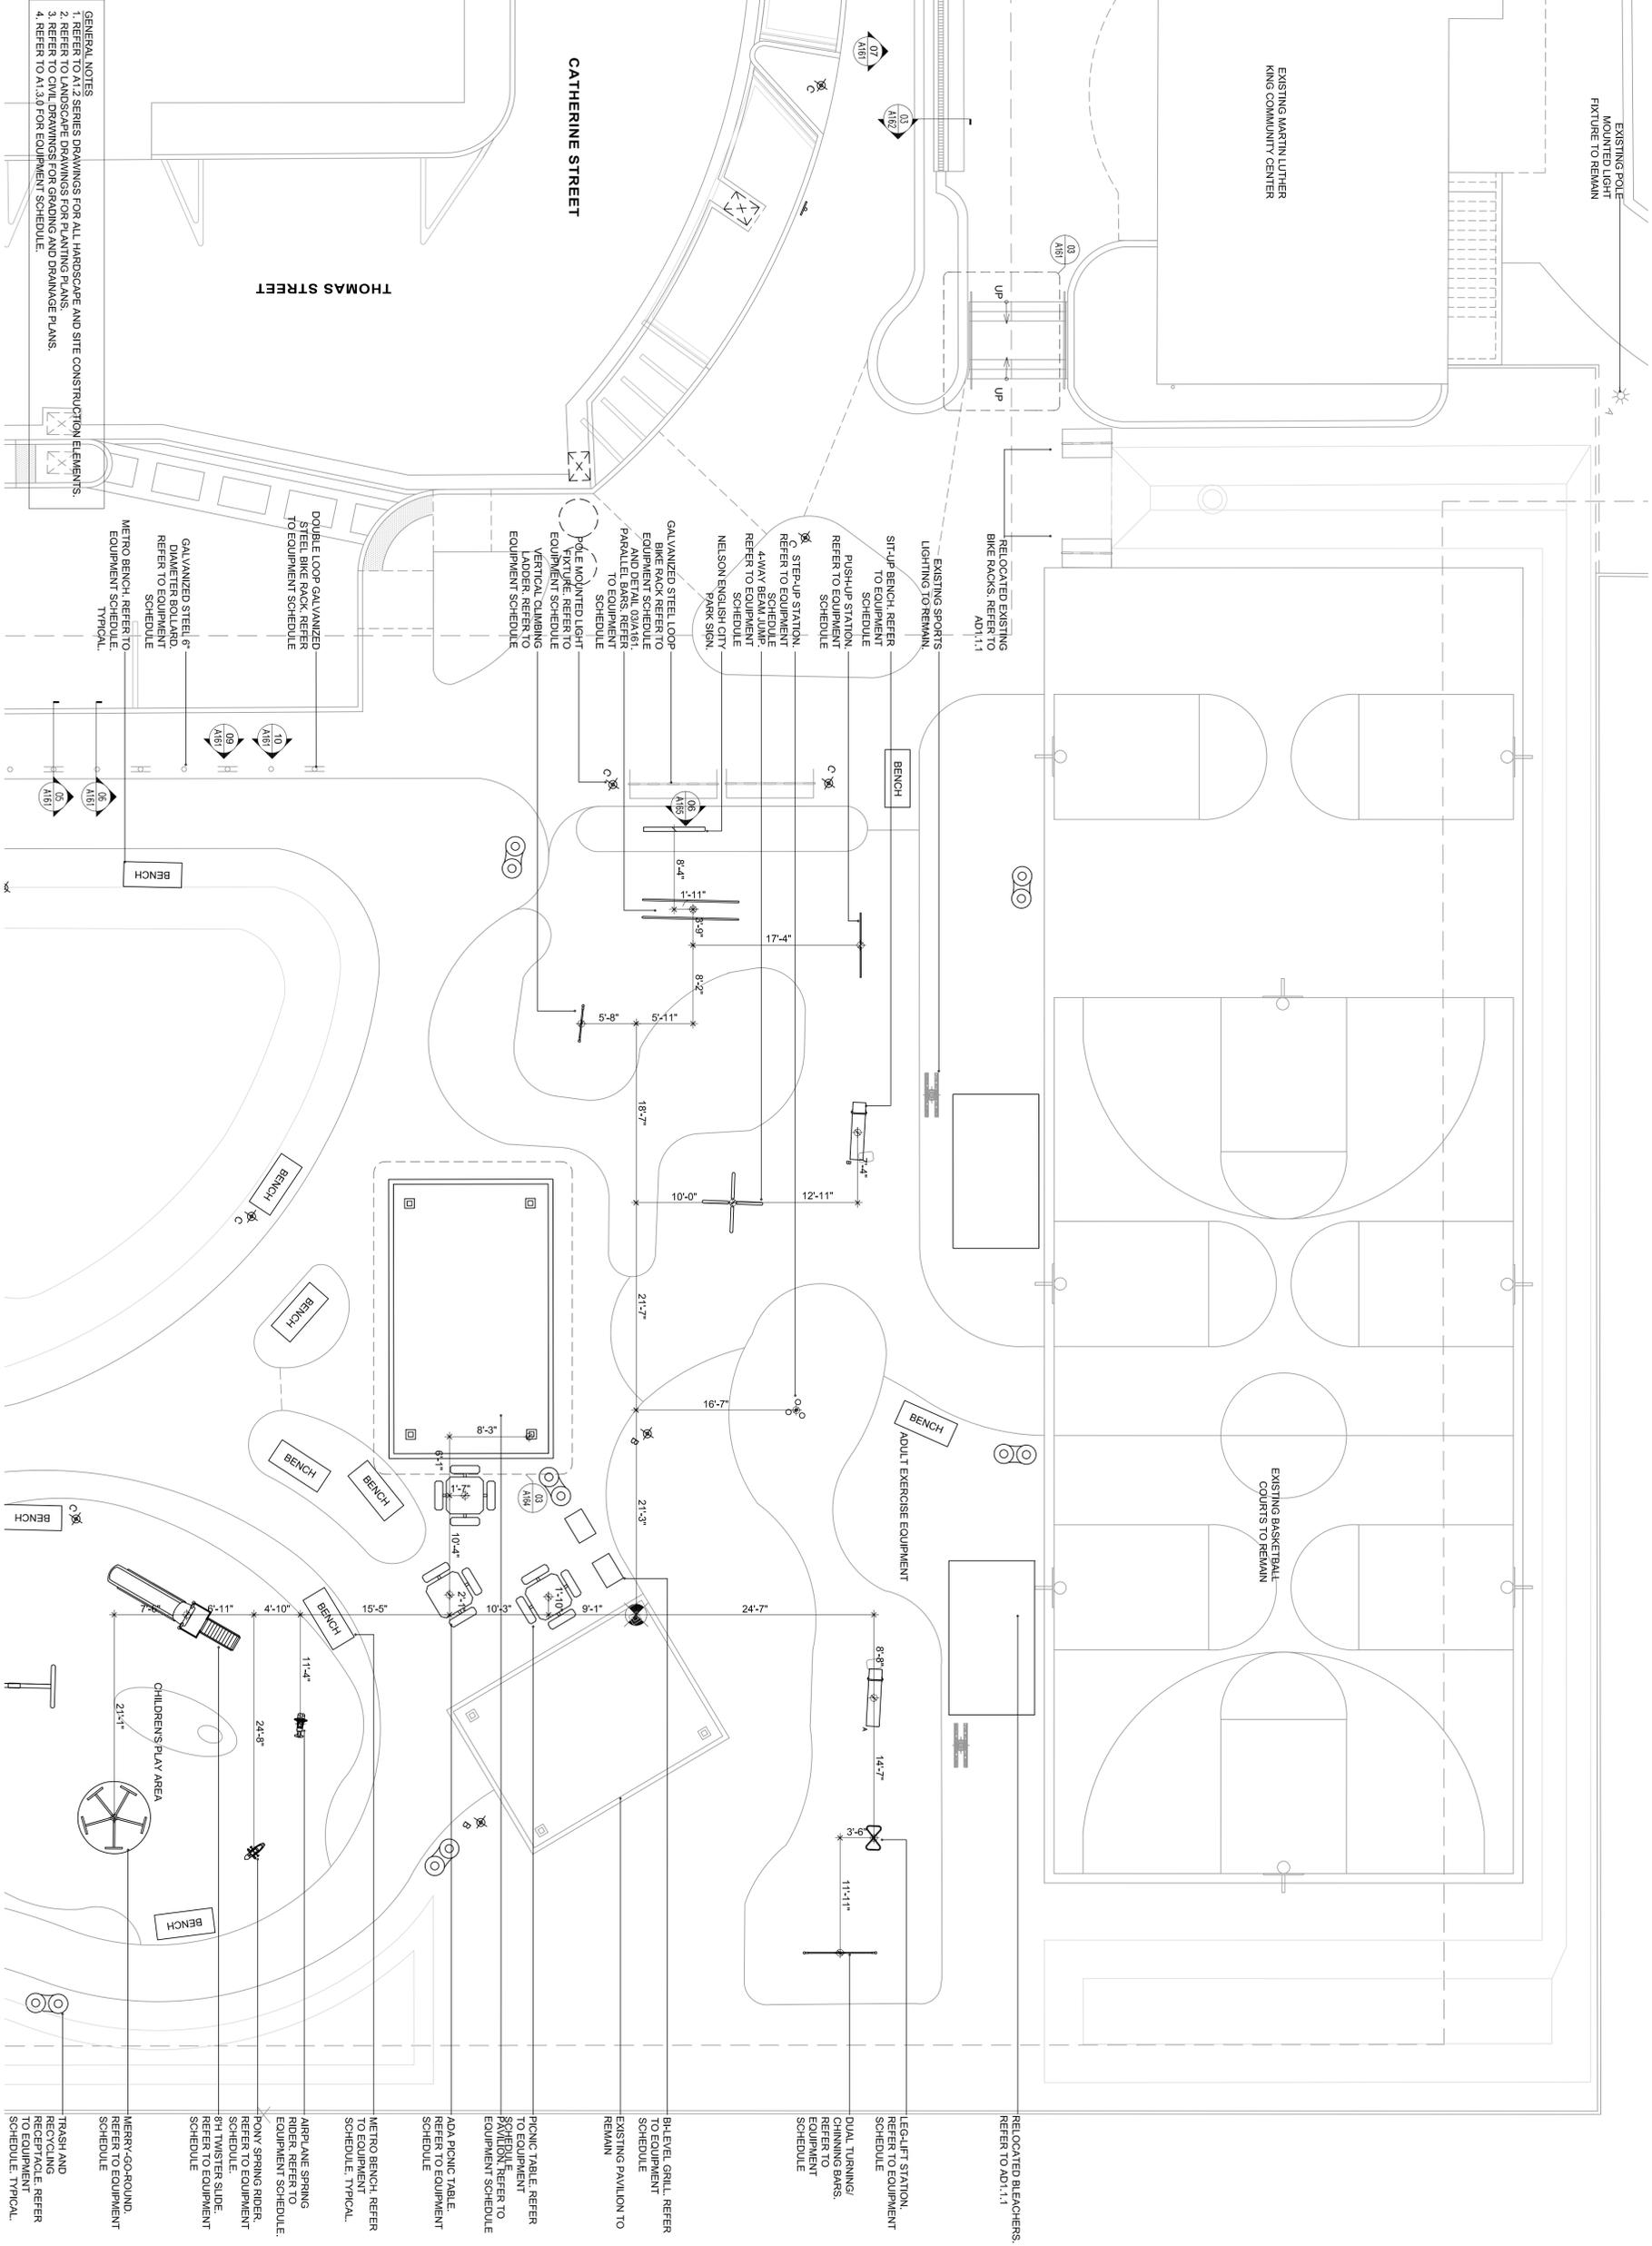


**GENERAL NOTES**  
1. REFER TO A1.2 SERIES DRAWINGS FOR ALL HARDSCAPE AND SITE CONSTRUCTION ELEMENTS.  
2. REFER TO LANDSCAPE DRAWINGS FOR PLANTING PLANS.  
3. REFER TO CIVIL DRAWINGS FOR GRADING AND DRAINAGE PLANS.  
4. REFER TO A1.3.9 FOR EQUIPMENT SCHEDULE.

**01 EQUIPMENT PLAN - ZONE B**  
SCALE: 1/8"=1'-0"


0 8 16 24  
GRAPHIC SCALE: 1/8" = 1'-0"

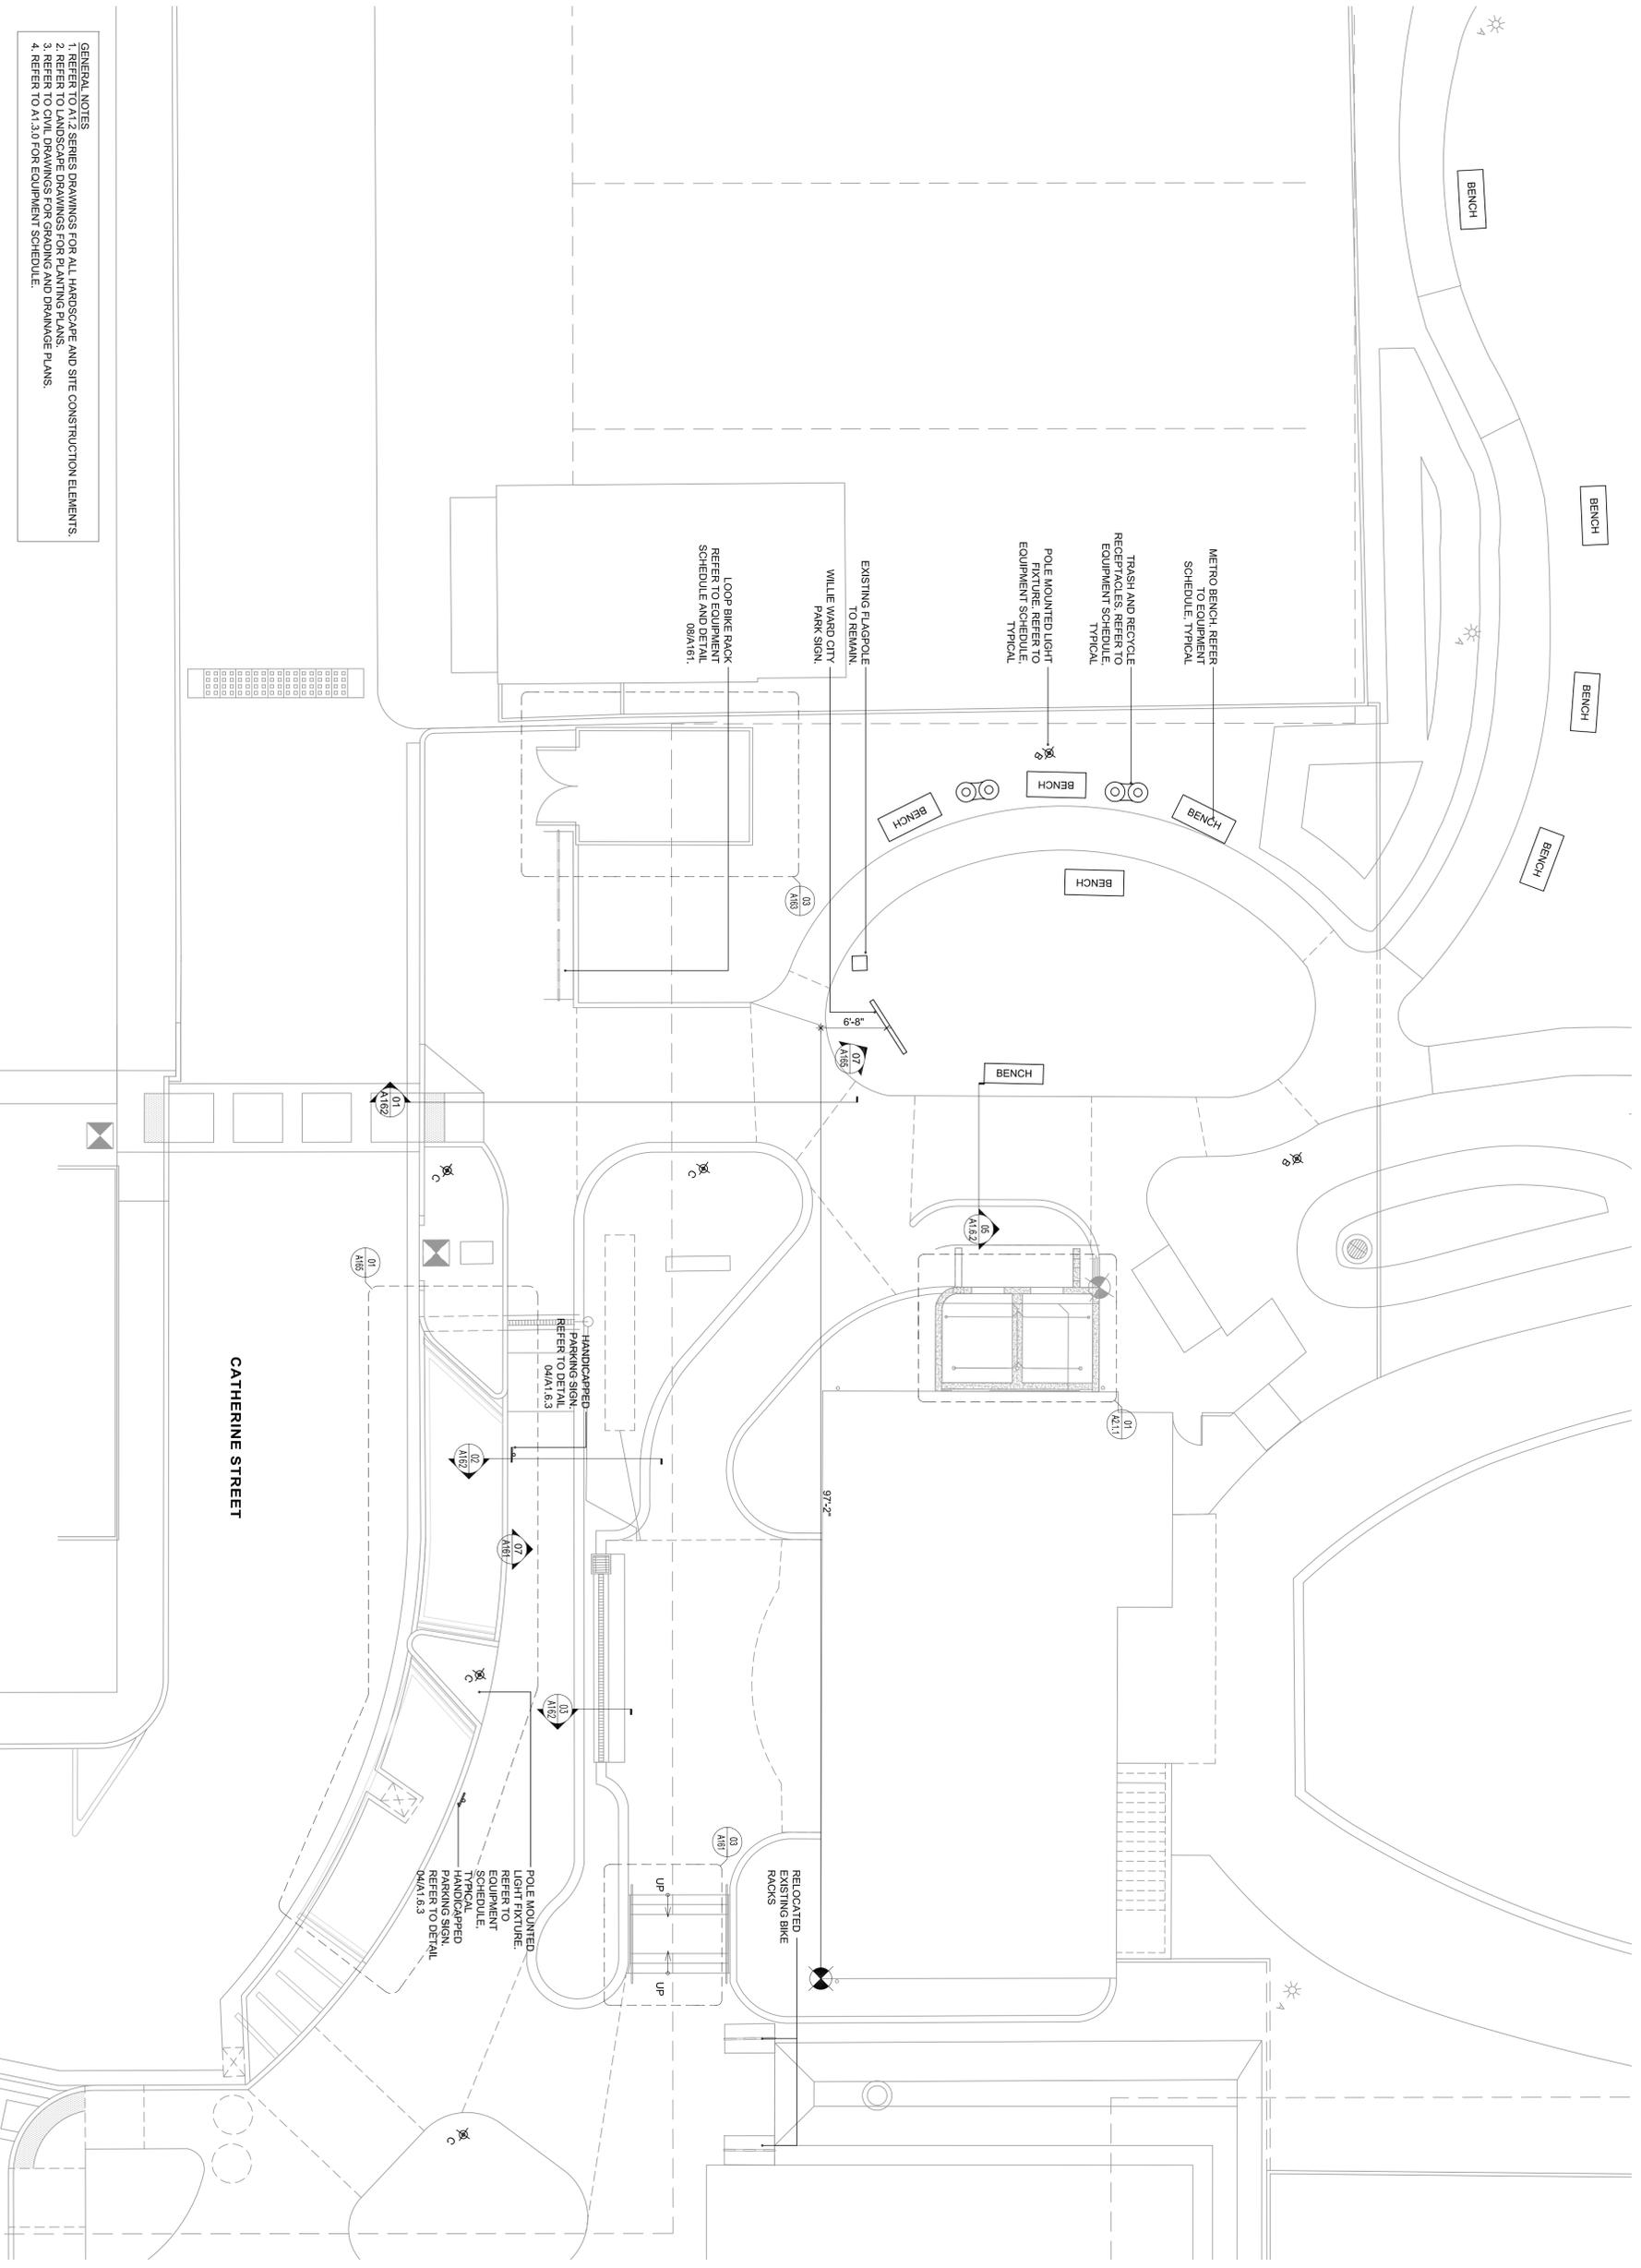

 - GENERAL NOTES
1. REFER TO A1.2 SERIES DRAWINGS FOR ALL HARDSCAPE AND SITE CONSTRUCTION ELEMENTS.
  2. REFER TO LANDSCAPE DRAWINGS FOR PLANTING PLANS.
  3. REFER TO CIVIL DRAWINGS FOR GRADING AND DRAINAGE PLANS.
  4. REFER TO A1.3.3 FOR EQUIPMENT SCHEDULE.



 **01**  
**EQUIPMENT PLAN - ZONE C**  
SCALE: 1/8"=1'-0"



**ARCHITECT:**  
**mbi | k2m**  
**ARCHITECTURE, INC.**  
Architecture, Interior Design,  
Procurement,  
Owner Representation,  
Specialty Consulting  
1001 Whitehead Street  
Key West, Florida 33040  
Key Tel: 305.292.7722  
Fax: 305.292.2182  
Email: info@mbi-k2m.com  
www.mbi-k2m.com  
PROJ. REG. A426001059  
Building Relationships  
Based on Trust and Respect  
Southern Florida | Washington DC

**Consultants:**  
CIVIL ENGINEER:  
Meridian Engineering, LLC  
LANDSCAPE ARCHITECT:  
Craig Reynolds, RLA

**Submissions:**  
July 28, 2011 - Initial Meeting at  
August 18, 2011 - Final Meeting at  
September 30, 2011 - HADC, Form  
Commission, Offer and Proposal  
January 4, 2012 - TIF Application  
January 18, 2012 - Revised Station  
Special Submittals  
January 27, 2012 - Final Station  
Special Submittals  
June 5, 2012 - City Public Hearing  
July 26, 2012 - City Public Hearing  
August 17, 2012 - HADC Construction  
Documents

**NELSON ENGLISH / WILLIE WARD  
PARK ENHANCEMENT PROJECT**  
**CITY OF KEY WEST**  
300 Catherine Street, Key West, Florida 33040

PLOTTED: 8/19/2012 12:48 PM  
Drawing Size: MK-11035  
2x4x8  
Drawn By: AAS  
Checked By: AAS  
Title: EQUIPMENT PLAN  
ZONE C

Sheet Number:  
**A1.3.3**  
Date: August 17, 2012  
©2012 by mbi | k2m Architecture, Inc.

Seal:


CONSULTANTS:  
CIVIL ENGINEER:  
Meredith Engineering, LLC  
LANDSCAPE ARCHITECT:  
Craig Reynolds, RLA

SUBMITTIONS:  
July 26, 2011 - Initial Meeting at  
August 18, 2011 - Final Meeting at  
September 30, 2011 - HADC, Town  
Commission, DPIC and Friends  
January 4, 2012 - TIF Application  
January 18, 2012 - Revised Siteplan  
February 27, 2012 - Revised Siteplan  
March 5, 2012 - Civil Review, Submittals  
March 16, 2012 - Civil Review, Submittals  
March 22, 2012 - HADC, Commission  
March 27, 2012 - HADC, Commission  
Revisions:  
Revisions:  
Revisions:

**NELSON ENGLISH / WILLIE WARD**  
**PARK ENHANCEMENT PROJECT**  
**CITY OF KEY WEST**  
300 Catherine Street, Key West, Florida 33040

PLOTTED: 8/19/2012 12:50 PM  
Drawing Size: 24x36 Project #: MK-11035  
Drawn By: ADS  
Checked By: ADS  
Title: EQUIPMENT PLAN  
ZONE D

Sheet Number:  
**A1.3.4**  
Date: August 17, 2012  
©2012 by mbi | k2m Architecture, Inc.

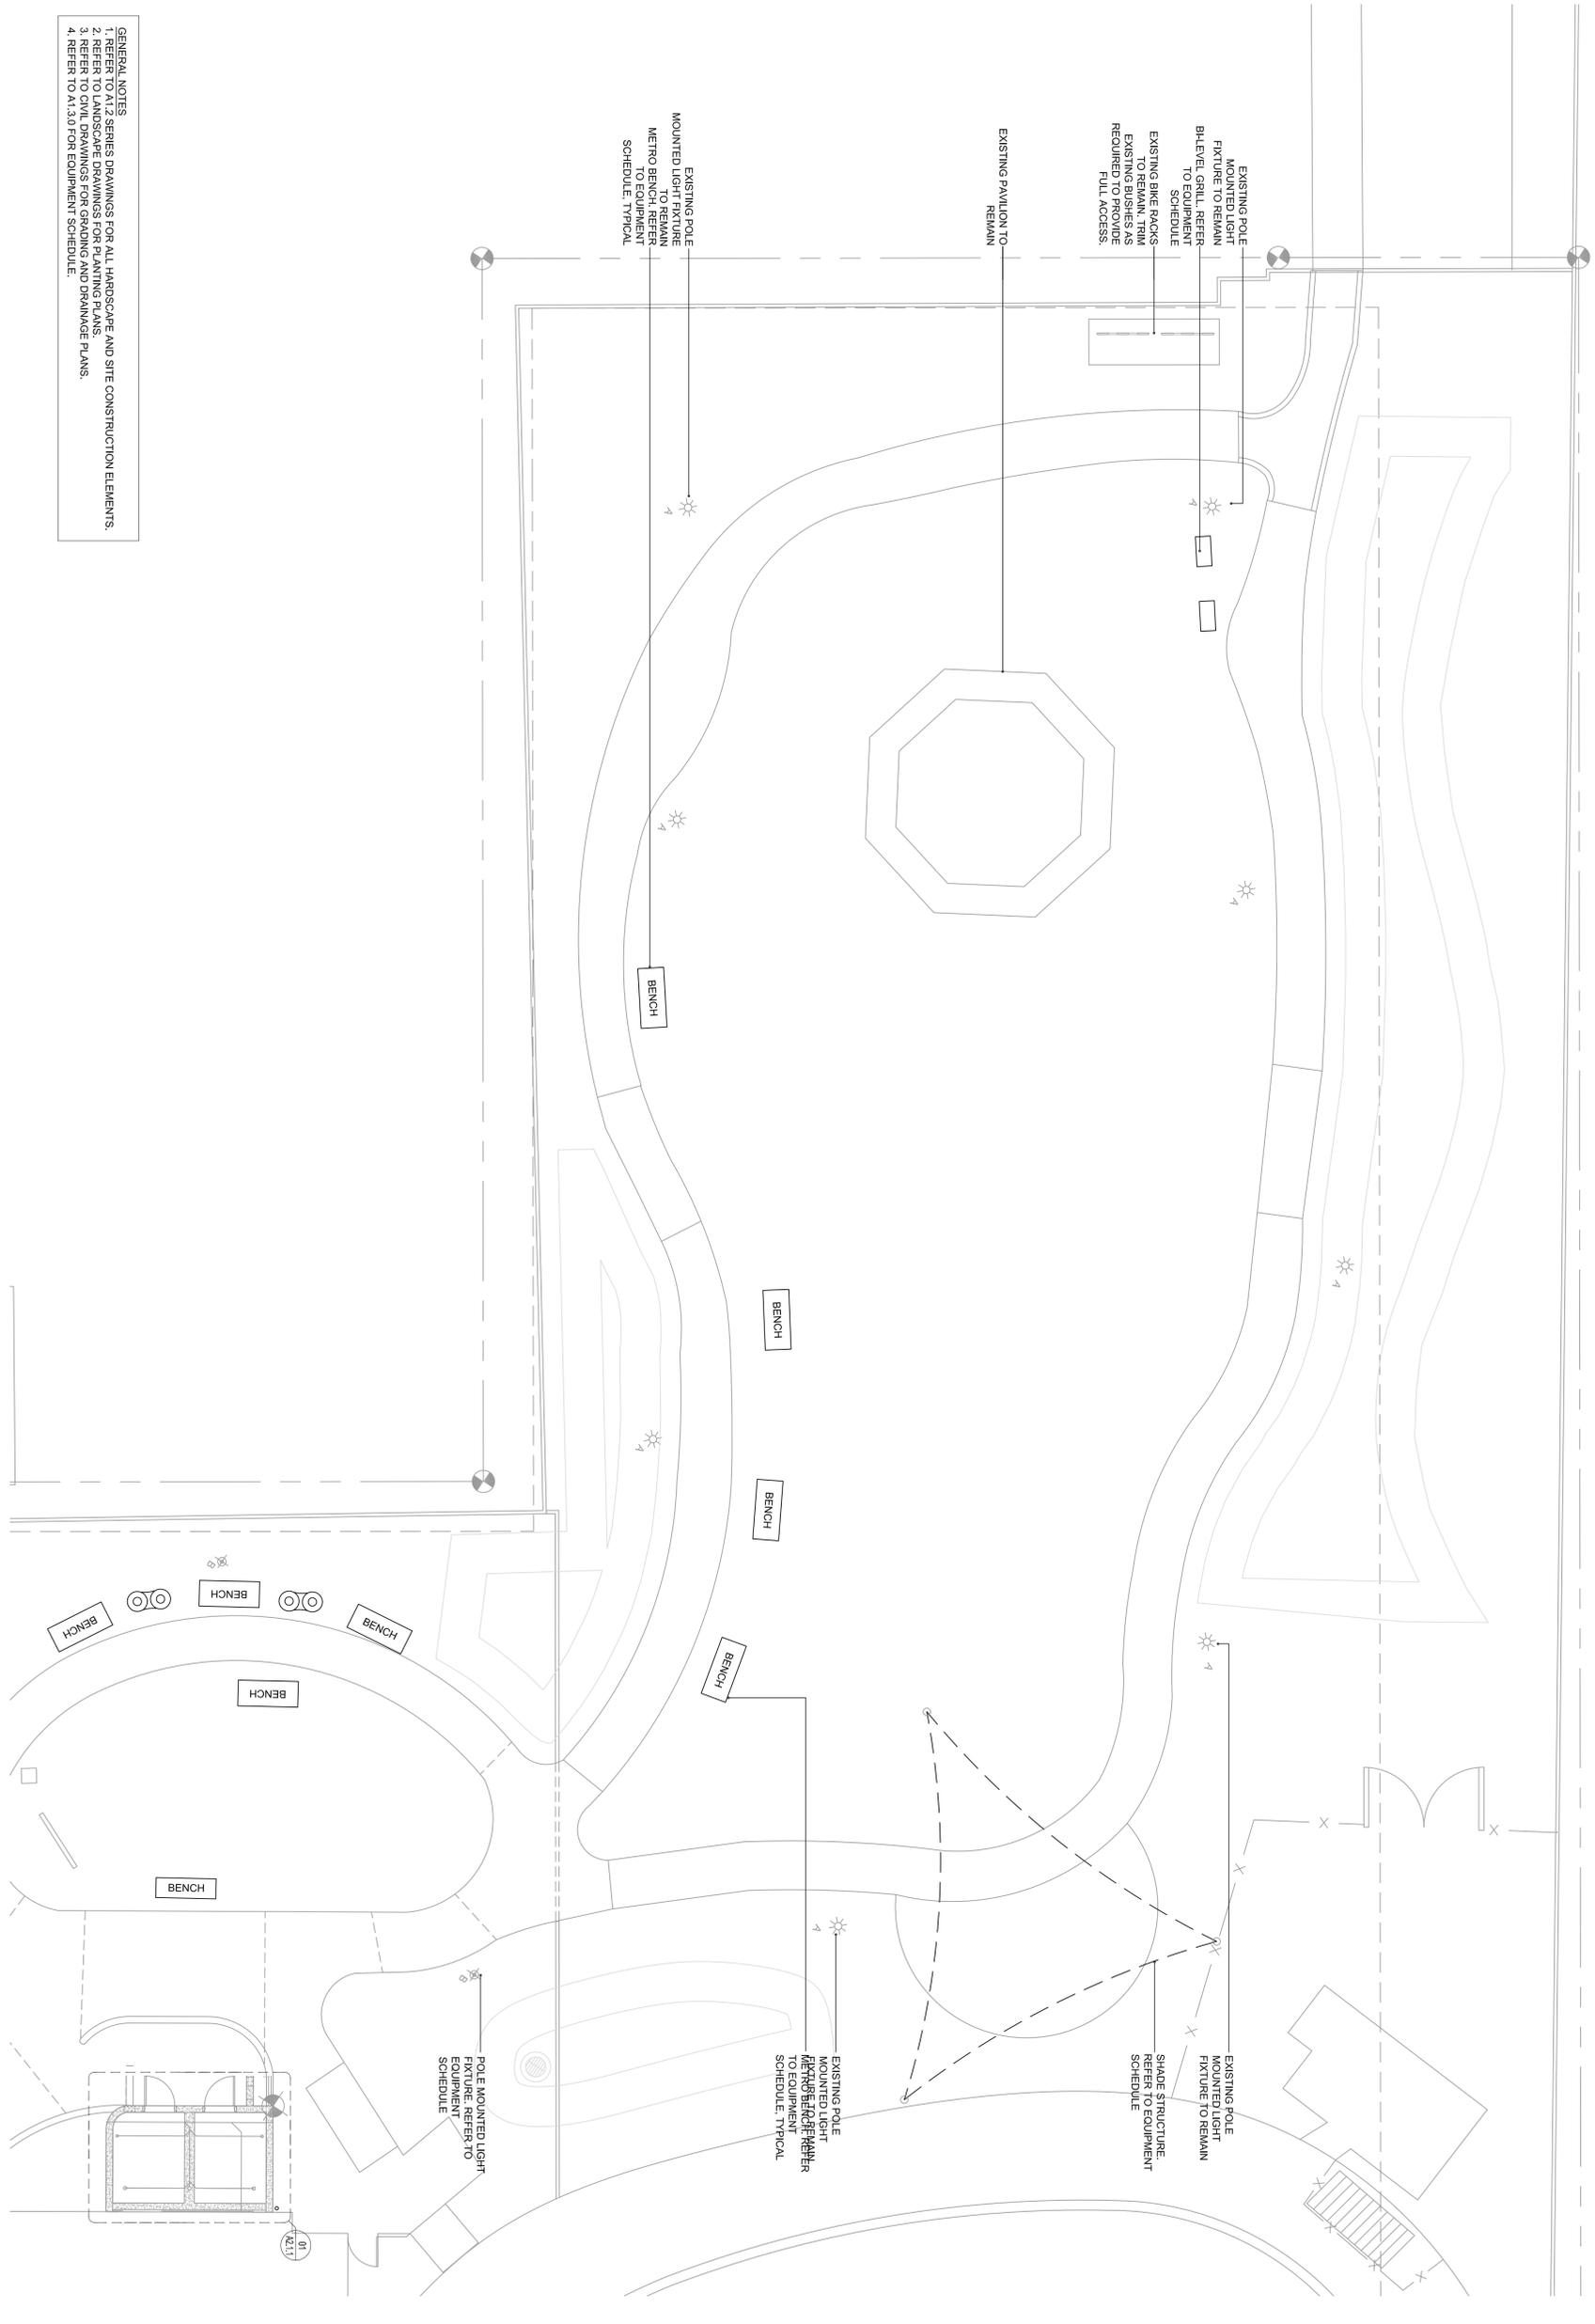

GENERAL NOTES:  
1. REFER TO A1.2 SERIES DRAWINGS FOR ALL HARDSCAPE AND SITE CONSTRUCTION ELEMENTS.  
2. REFER TO LANDSCAPE DRAWINGS FOR PLANTING PLANS.  
3. REFER TO CIVIL DRAWINGS FOR GRADING AND DRAINAGE PLANS.  
4. REFER TO A1.3.0 FOR EQUIPMENT SCHEDULE.

01  
A1.3.4

**EQUIPMENT PLAN - ZONE D**  
SCALE: 1/8"=1'-0"

