



BAR IS TWO INCHES ON ORIGINAL DRAWINGS  
IF NOT TWO INCHES ON THIS SHEET ADJUST  
SCALES ACCORDINGLY.

**GENERAL NOTES**

1. BASE MAP INFORMATION WAS TAKEN FROM A SURVEY PREPARED BY FRED HILDEBRANDT. THE BASE MAP INFORMATION IS TYPICALLY SHOWN IN GRAY/LIGHT LINE WEIGHT. THE UTILITIES LOCATED AS PART OF THIS PROJECT ARE SHOWN IN COLOR IN ACCORDANCE WITH THE LEGEND.


SHEET C-2

SHEET C-3

SHEET C-4

SHEET C-5

SHEET C-6

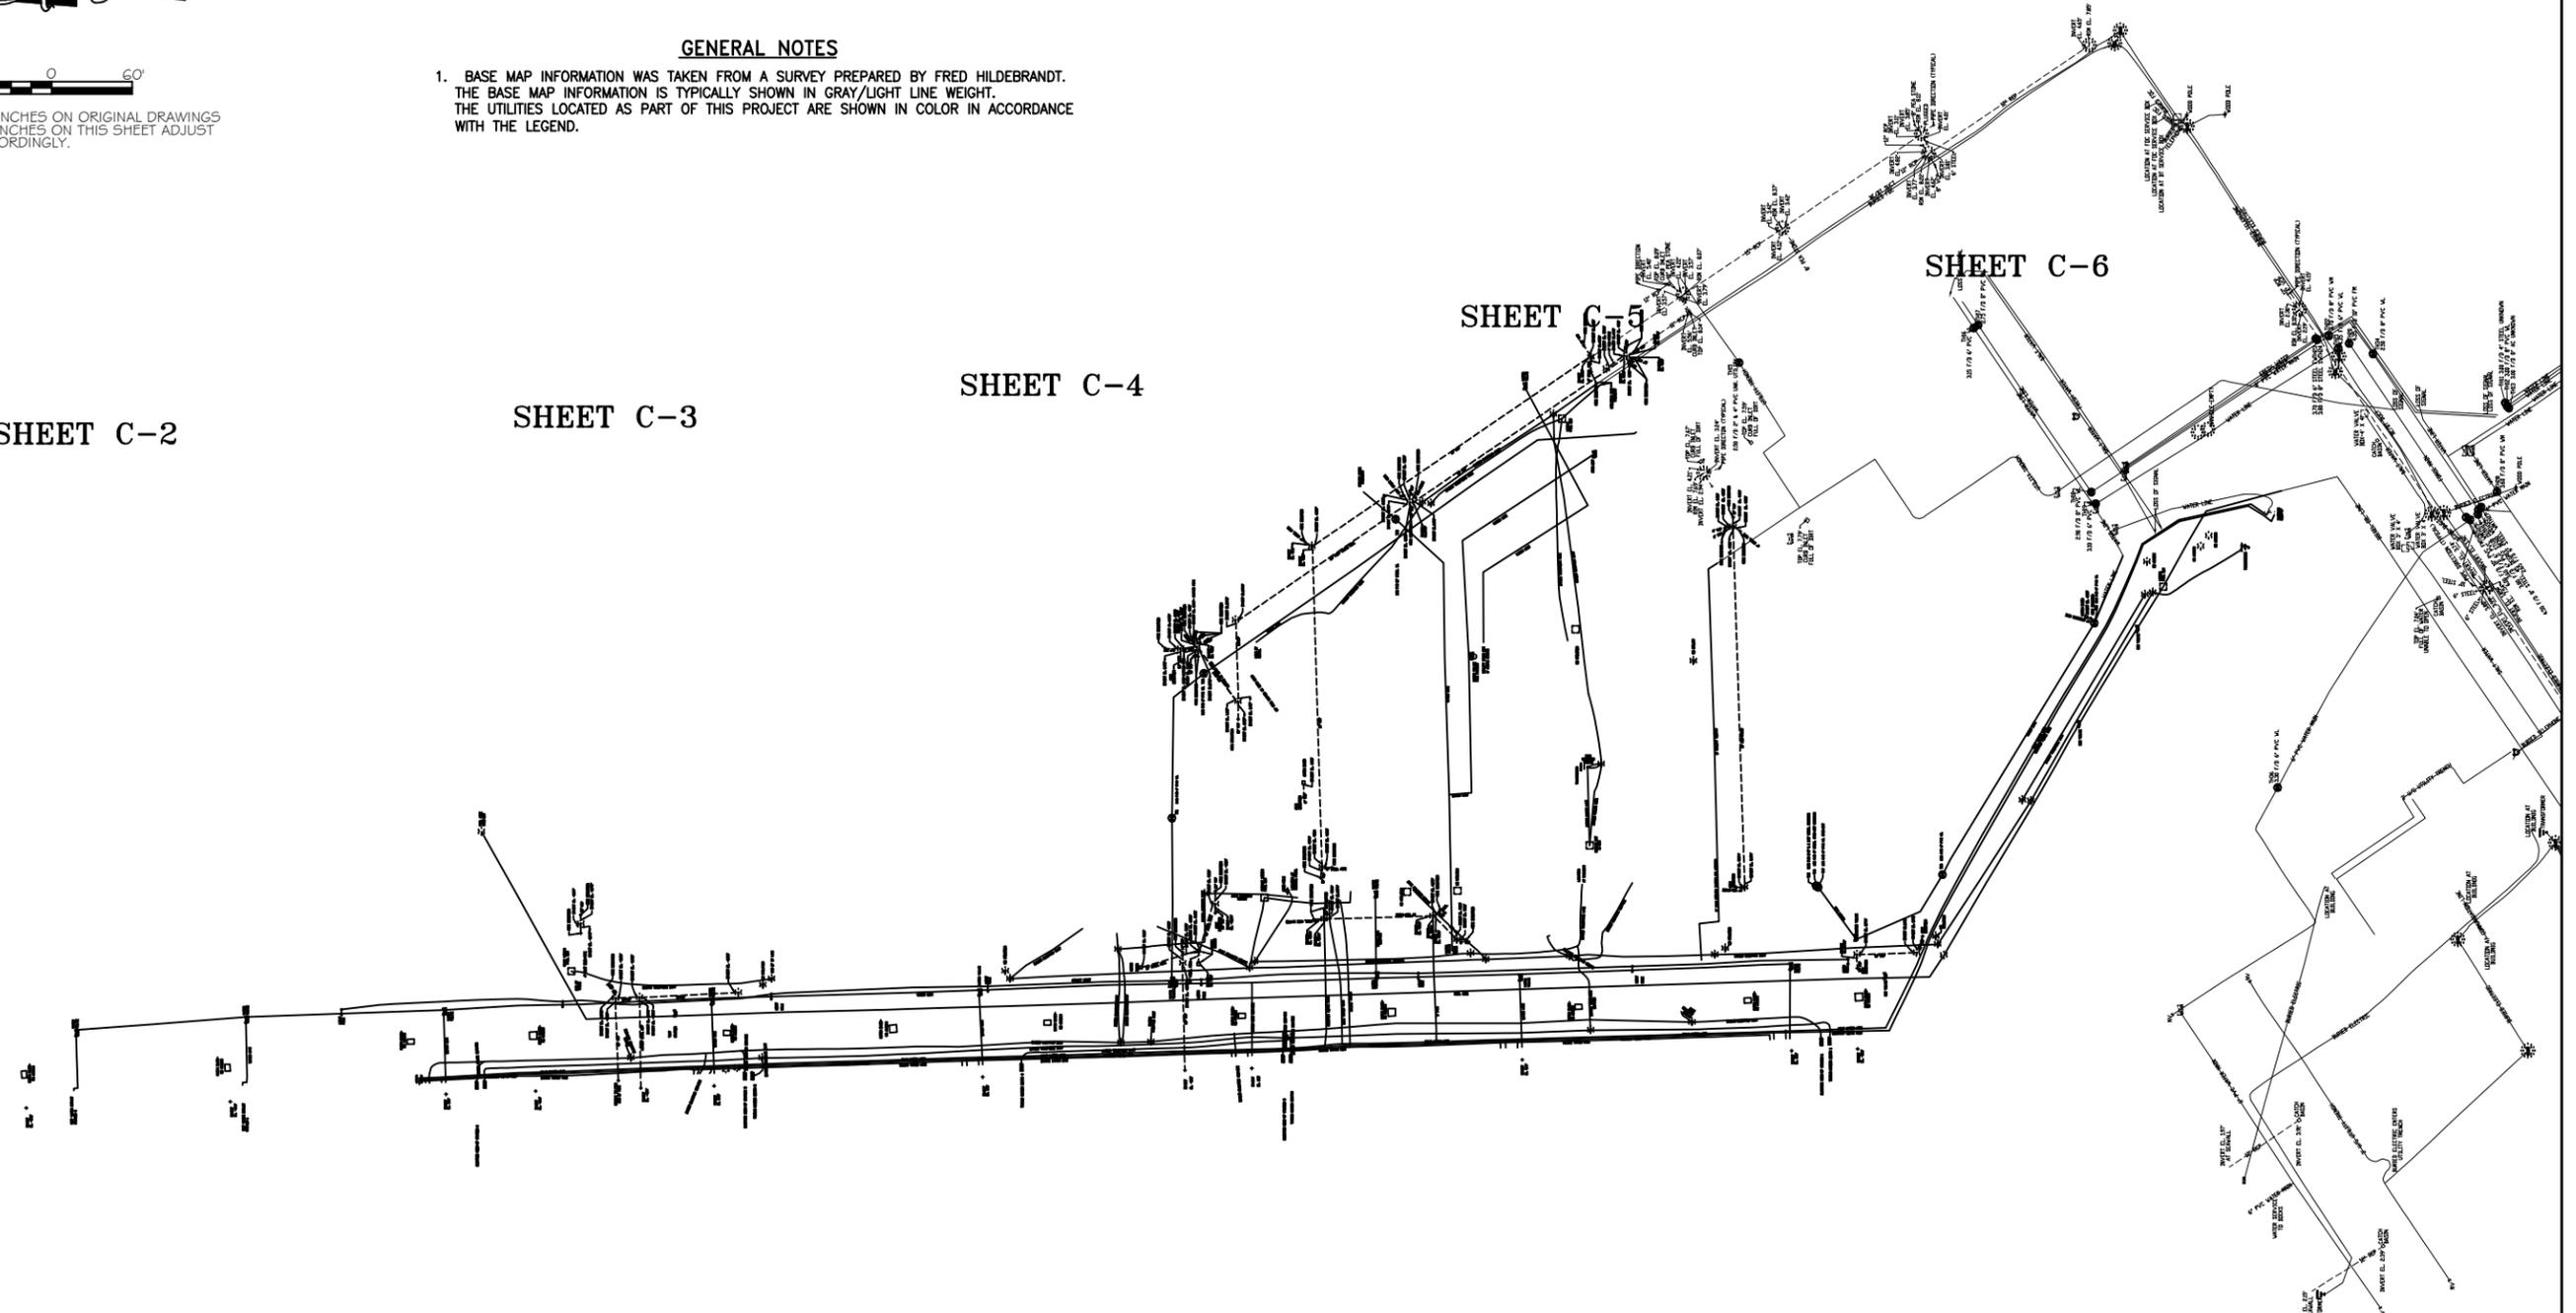

**SURVEY LEGEND**

- EXIST. GAS LINE
- EXIST. TELEPHONE DUCT
- EXIST. STORM WATER SEWER LINE
- EXIST. SANITARY SEWER LINE
- EXIST. WATER LINE
- EXIST. ELECTRICAL LINE

**P E & D , Inc.**  
Certificate of Authorization #8579  
**Perez Engineering  
& Development, Inc.**  
3210 FLAGLER AVENUE  
Key West, FL 33040  
ph: (305) 293-9440 \* fax: (305) 296-0243

| No. | Revision/Issue | Date |
|-----|----------------|------|
|     |                |      |

|              |     |          |             |
|--------------|-----|----------|-------------|
| Designed By: | AEP | Project: | UTILITY.DWG |
| Checked By:  | AEP | Date:    | 1/23/03     |
| Drawn By:    | GKG | Scale:   | AS NOTED    |



**City of Key West**

**East Quay  
Subsurface Utility Map**  
KEY WEST, FL

SITE PLAN


ALLEN E. PEREZ P.E.#51468

NOT VALID FOR CONSTRUCTION UNLESS  
SIGNED AND SEALED IN THIS BLOCK

Sheet  
**C-1**

20' 0 20'

BAR IS TWO INCHES ON ORIGINAL DRAWINGS  
IF NOT TWO INCHES ON THIS SHEET ADJUST  
SCALES ACCORDINGLY.

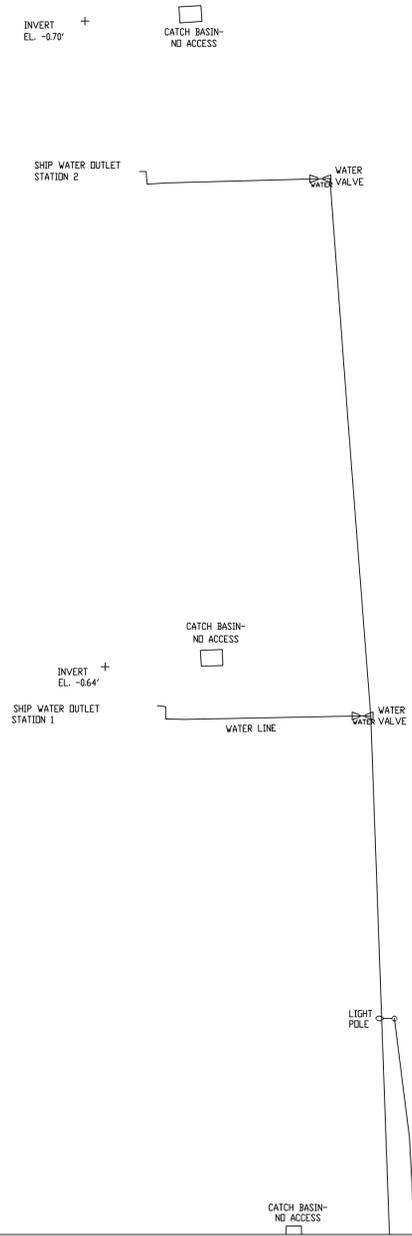

**LEGEND**

- ===== GAS LINE
- TELEPHONE DUCT
- - - - - STORM WATER SEWER LINE
- ===== SANATARY SEWER LINE
- ===== WATER LINE
- ===== ELECTRICAL LINE

SEE SHEET C-3

**P E & D , Inc.**  
Certificate of Authorization #8579  
**Perez Engineering  
& Development, Inc.**  
3210 FLAGLER AVENUE  
Key West, FL 33040  
ph: (305) 293-9440 \* fax: (305) 296-0243

| No. | Revision/Issue | Date |
|-----|----------------|------|
|     |                |      |
|     |                |      |

|              |     |          |             |
|--------------|-----|----------|-------------|
| Designed By: | AEP | Project: | UTILITY.DWG |
| Checked By:  | AEP | Date:    | 1/23/03     |
| Drawn By:    | GKG | Scale:   | 1" = 20'    |



**City of Key West**


**East Quay  
Subsurface Utility Map**  
KEY WEST, FL

SUBSURFACE UTILITY MAP

|  |                     |
|--|---------------------|
| ALLEN E. PEREZ   | P.E.#51468          |
| NOT VALID FOR CONSTRUCTION UNLESS<br>SIGNED AND SEALED IN THIS BLOCK | Sheet<br><b>C-2</b> |



BAR IS TWO INCHES ON ORIGINAL DRAWINGS  
IF NOT TWO INCHES ON THIS SHEET ADJUST  
SCALES ACCORDINGLY.

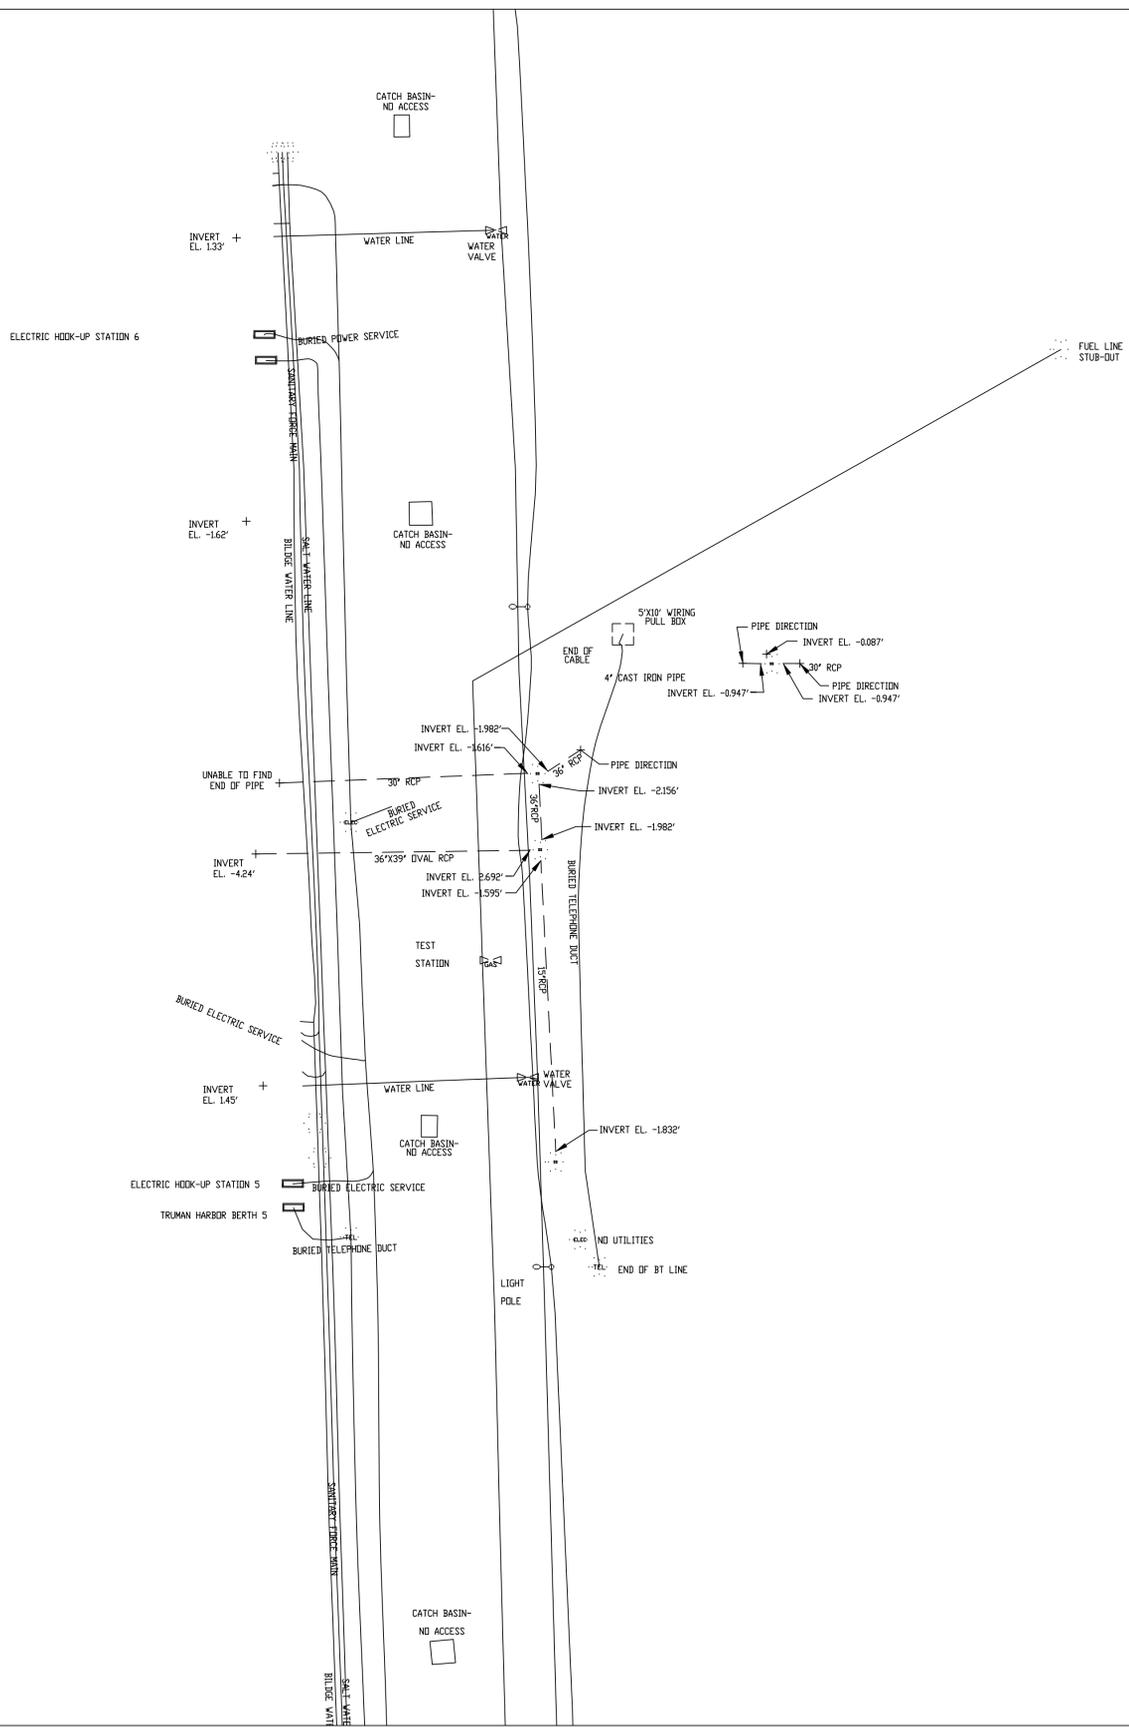

LEGEND

- ===== GAS LINE
- TELEPHONE DUCT
- STORM WATER SEWER LINE
- SANITARY SEWER LINE
- ===== WATER LINE
- ELECTRICAL LINE

CVProgram Files\AutoCAD Architectural Edition\acad\East\_Bay\TBC\img\grouplogo.jpg

**P E & D , Inc.**  
Certificate of Authorization #8579  
**Perez Engineering & Development, Inc.**  
3210 FLAGLER AVENUE  
Key West, FL 33040  
ph: (305) 293-9440 \* fax: (305) 296-0243

| No. | Revision/Issue | Date |
|-----|----------------|------|
|     |                |      |


|              |     |          |             |
|--------------|-----|----------|-------------|
| Designed By: | AEP | Project: | UTILITY.DWG |
| Checked By:  | AEP | Date:    | 1/23/03     |
| Drawn By:    | GKG | Scale:   | 1" = 20'    |




**City of Key West**

 **East Quay  
Subsurface Utility Map**  
KEY WEST, FL  
SUBSURFACE UTILITY MAP

|  |            |
|--|------------|
| ALLEN E. PEREZ   | P.E.#51468 |
| NOT VALID FOR CONSTRUCTION UNLESS<br>SIGNED AND SEALED IN THIS BLOCK |            |
| Sheet  | C-3        |



BAR IS TWO INCHES ON ORIGINAL DRAWINGS  
IF NOT TWO INCHES ON THIS SHEET ADJUST  
SCALES ACCORDINGLY.

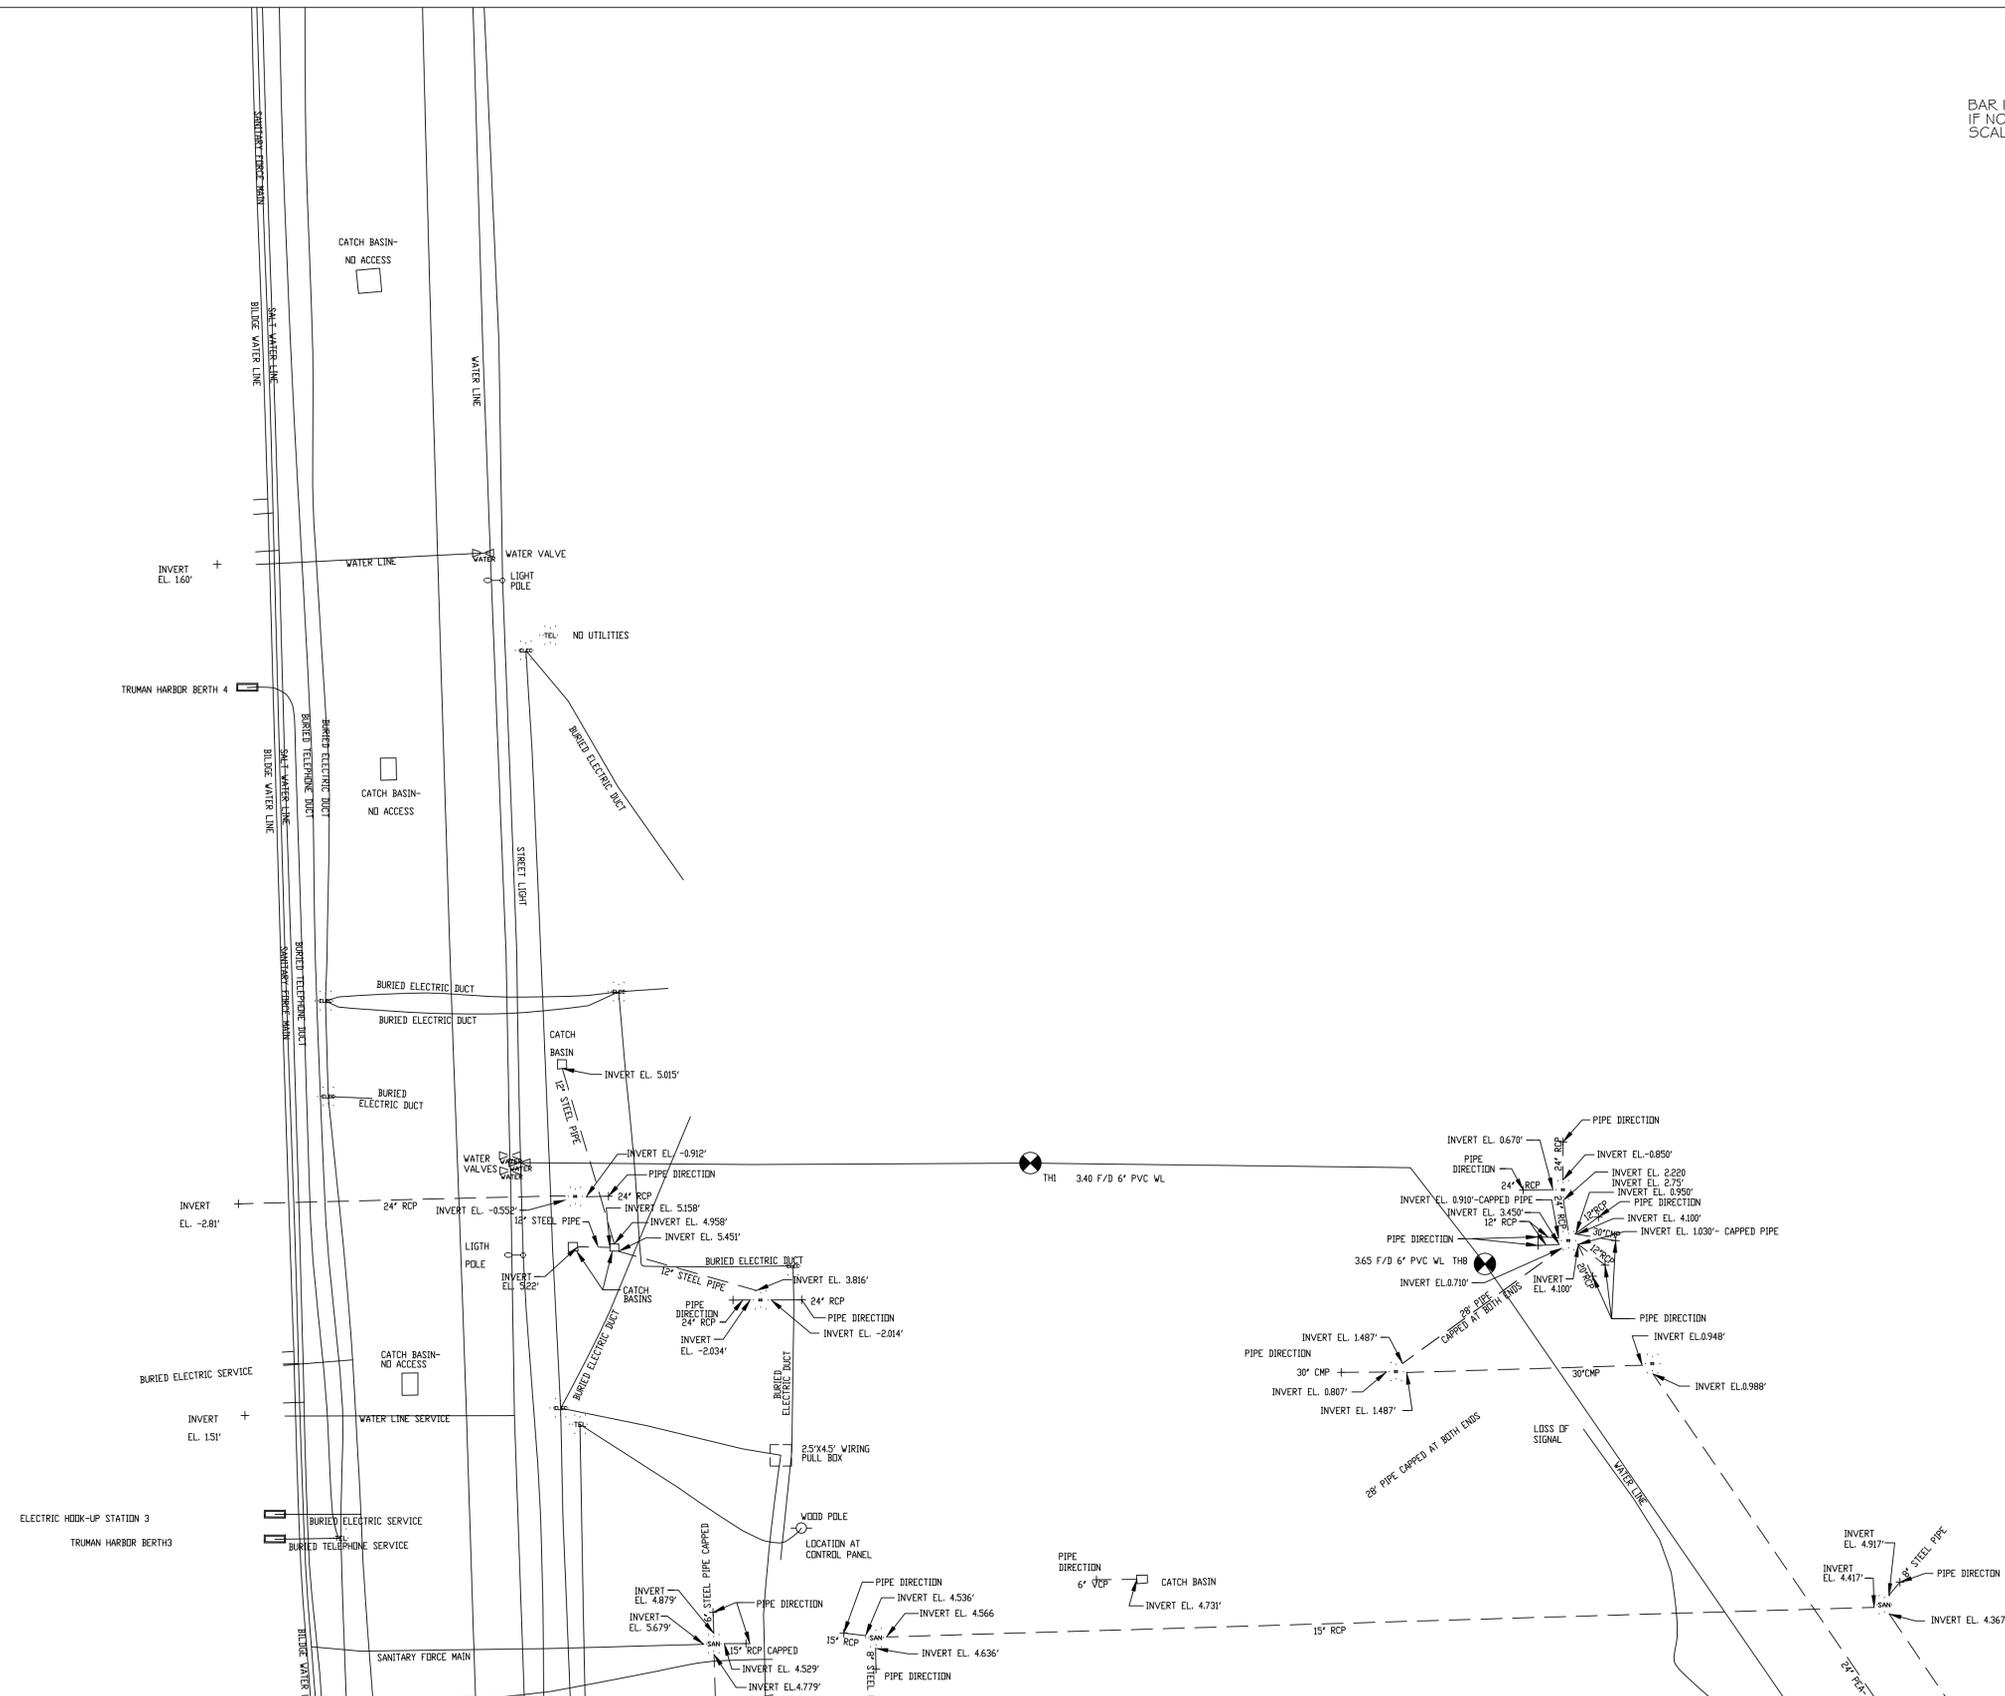

**LEGEND**

- GAS LINE
- TELEPHONE DUCT
- STORM WATER SEWER LINE
- SANITARY SEWER LINE
- WATER LINE
- ELECTRICAL LINE

**P E & D , Inc.**  
Certificate of Authorization #8579  
**Perez Engineering & Development, Inc.**  
3210 FLAGLER AVENUE  
Key West, FL 33040  
ph: (305) 293-9440 \* fax: (305) 296-0243

| No. | Revision/Issue | Date |
|-----|----------------|------|
|     |                |      |

 

|              |     |          |             |
|--------------|-----|----------|-------------|
| Designed By: | AEP | Project: | UTILITY.DWG |
| Checked By:  | AEP | Date:    | 1/23/03     |
| Drawn By:    | GKG | Scale:   | 1" = 20'    |



**City of Key West**

**East Quay  
Subsurface Utility Map**  
KEY WEST, FL  
**SUBSURFACE UTILITY MAP**

|  |            |
|--|------------|
| ALLEN E. PEREZ   | P.E.#51468 |
| NOT VALID FOR CONSTRUCTION UNLESS<br>SIGNED AND SEALED IN THIS BLOCK |            |
| Sheet  | C-4        |

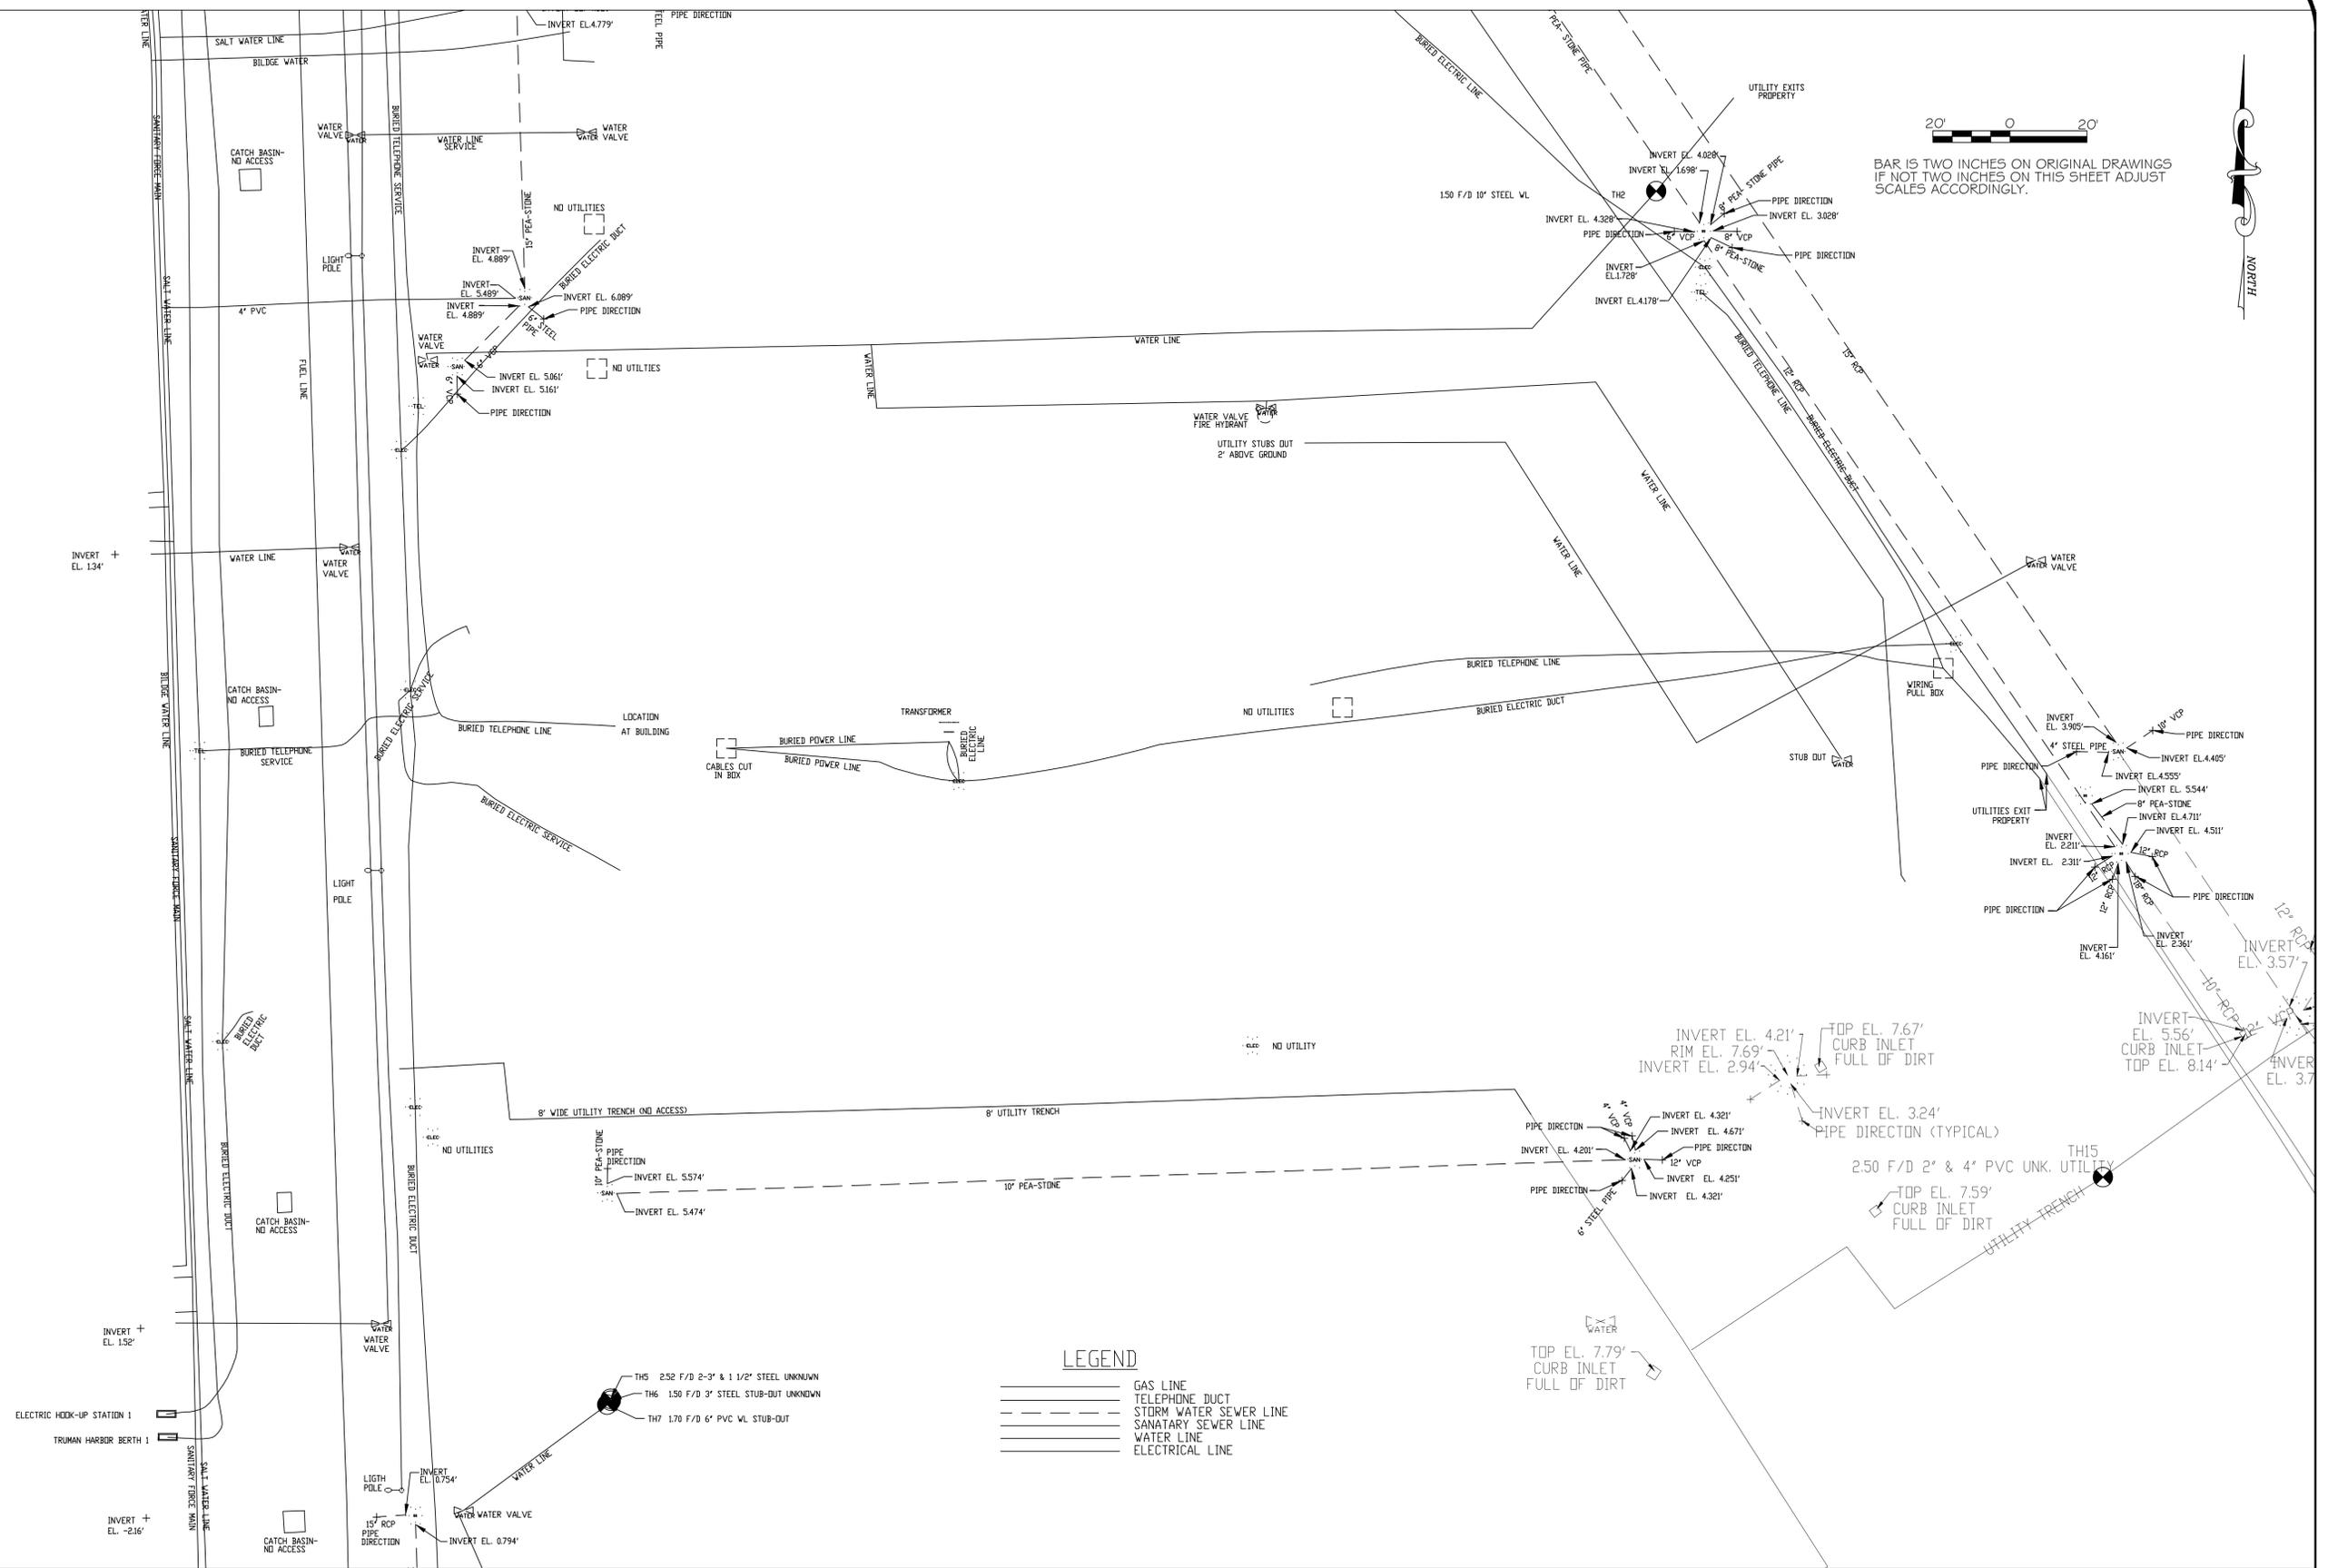

BAR IS TWO INCHES ON ORIGINAL DRAWINGS IF NOT TWO INCHES ON THIS SHEET ADJUST SCALES ACCORDINGLY.



**LEGEND**

- GAS LINE
- TELEPHONE DUCT
- - - - - STORM WATER SEWER LINE
- · - · - · SANITARY SEWER LINE
- WATER LINE
- ELECTRICAL LINE

**P E & D , Inc.**  
 Certificate of Authorization #8579  
**Perez Engineering & Development, Inc.**  
 3210 FLAGLER AVENUE  
 Key West, FL 33040  
 ph: (305) 293-9440 \* fax: (305) 296-0243

| No. | Revision/Issue | Date |
|-----|----------------|------|
|     |                |      |


|              |     |          |             |
|--------------|-----|----------|-------------|
| Designed By: | AEP | Project: | UTILITY.DWG |
| Checked By:  | AEP | Date:    | 1/23/03     |
| Drawn By:    | GKG | Scale:   | 1" = 20'    |



**City of Key West**

**East Quay Subsurface Utility Map**  
 KEY WEST, FL  
**SUBSURFACE UTILITY MAP**

|   |                     |
|---|---------------------|
| ALLEN E. PEREZ  | P.E.#51468          |
| NOT VALID FOR CONSTRUCTION UNLESS SIGNED AND SEALED IN THIS BLOCK | Sheet<br><b>C-5</b> |

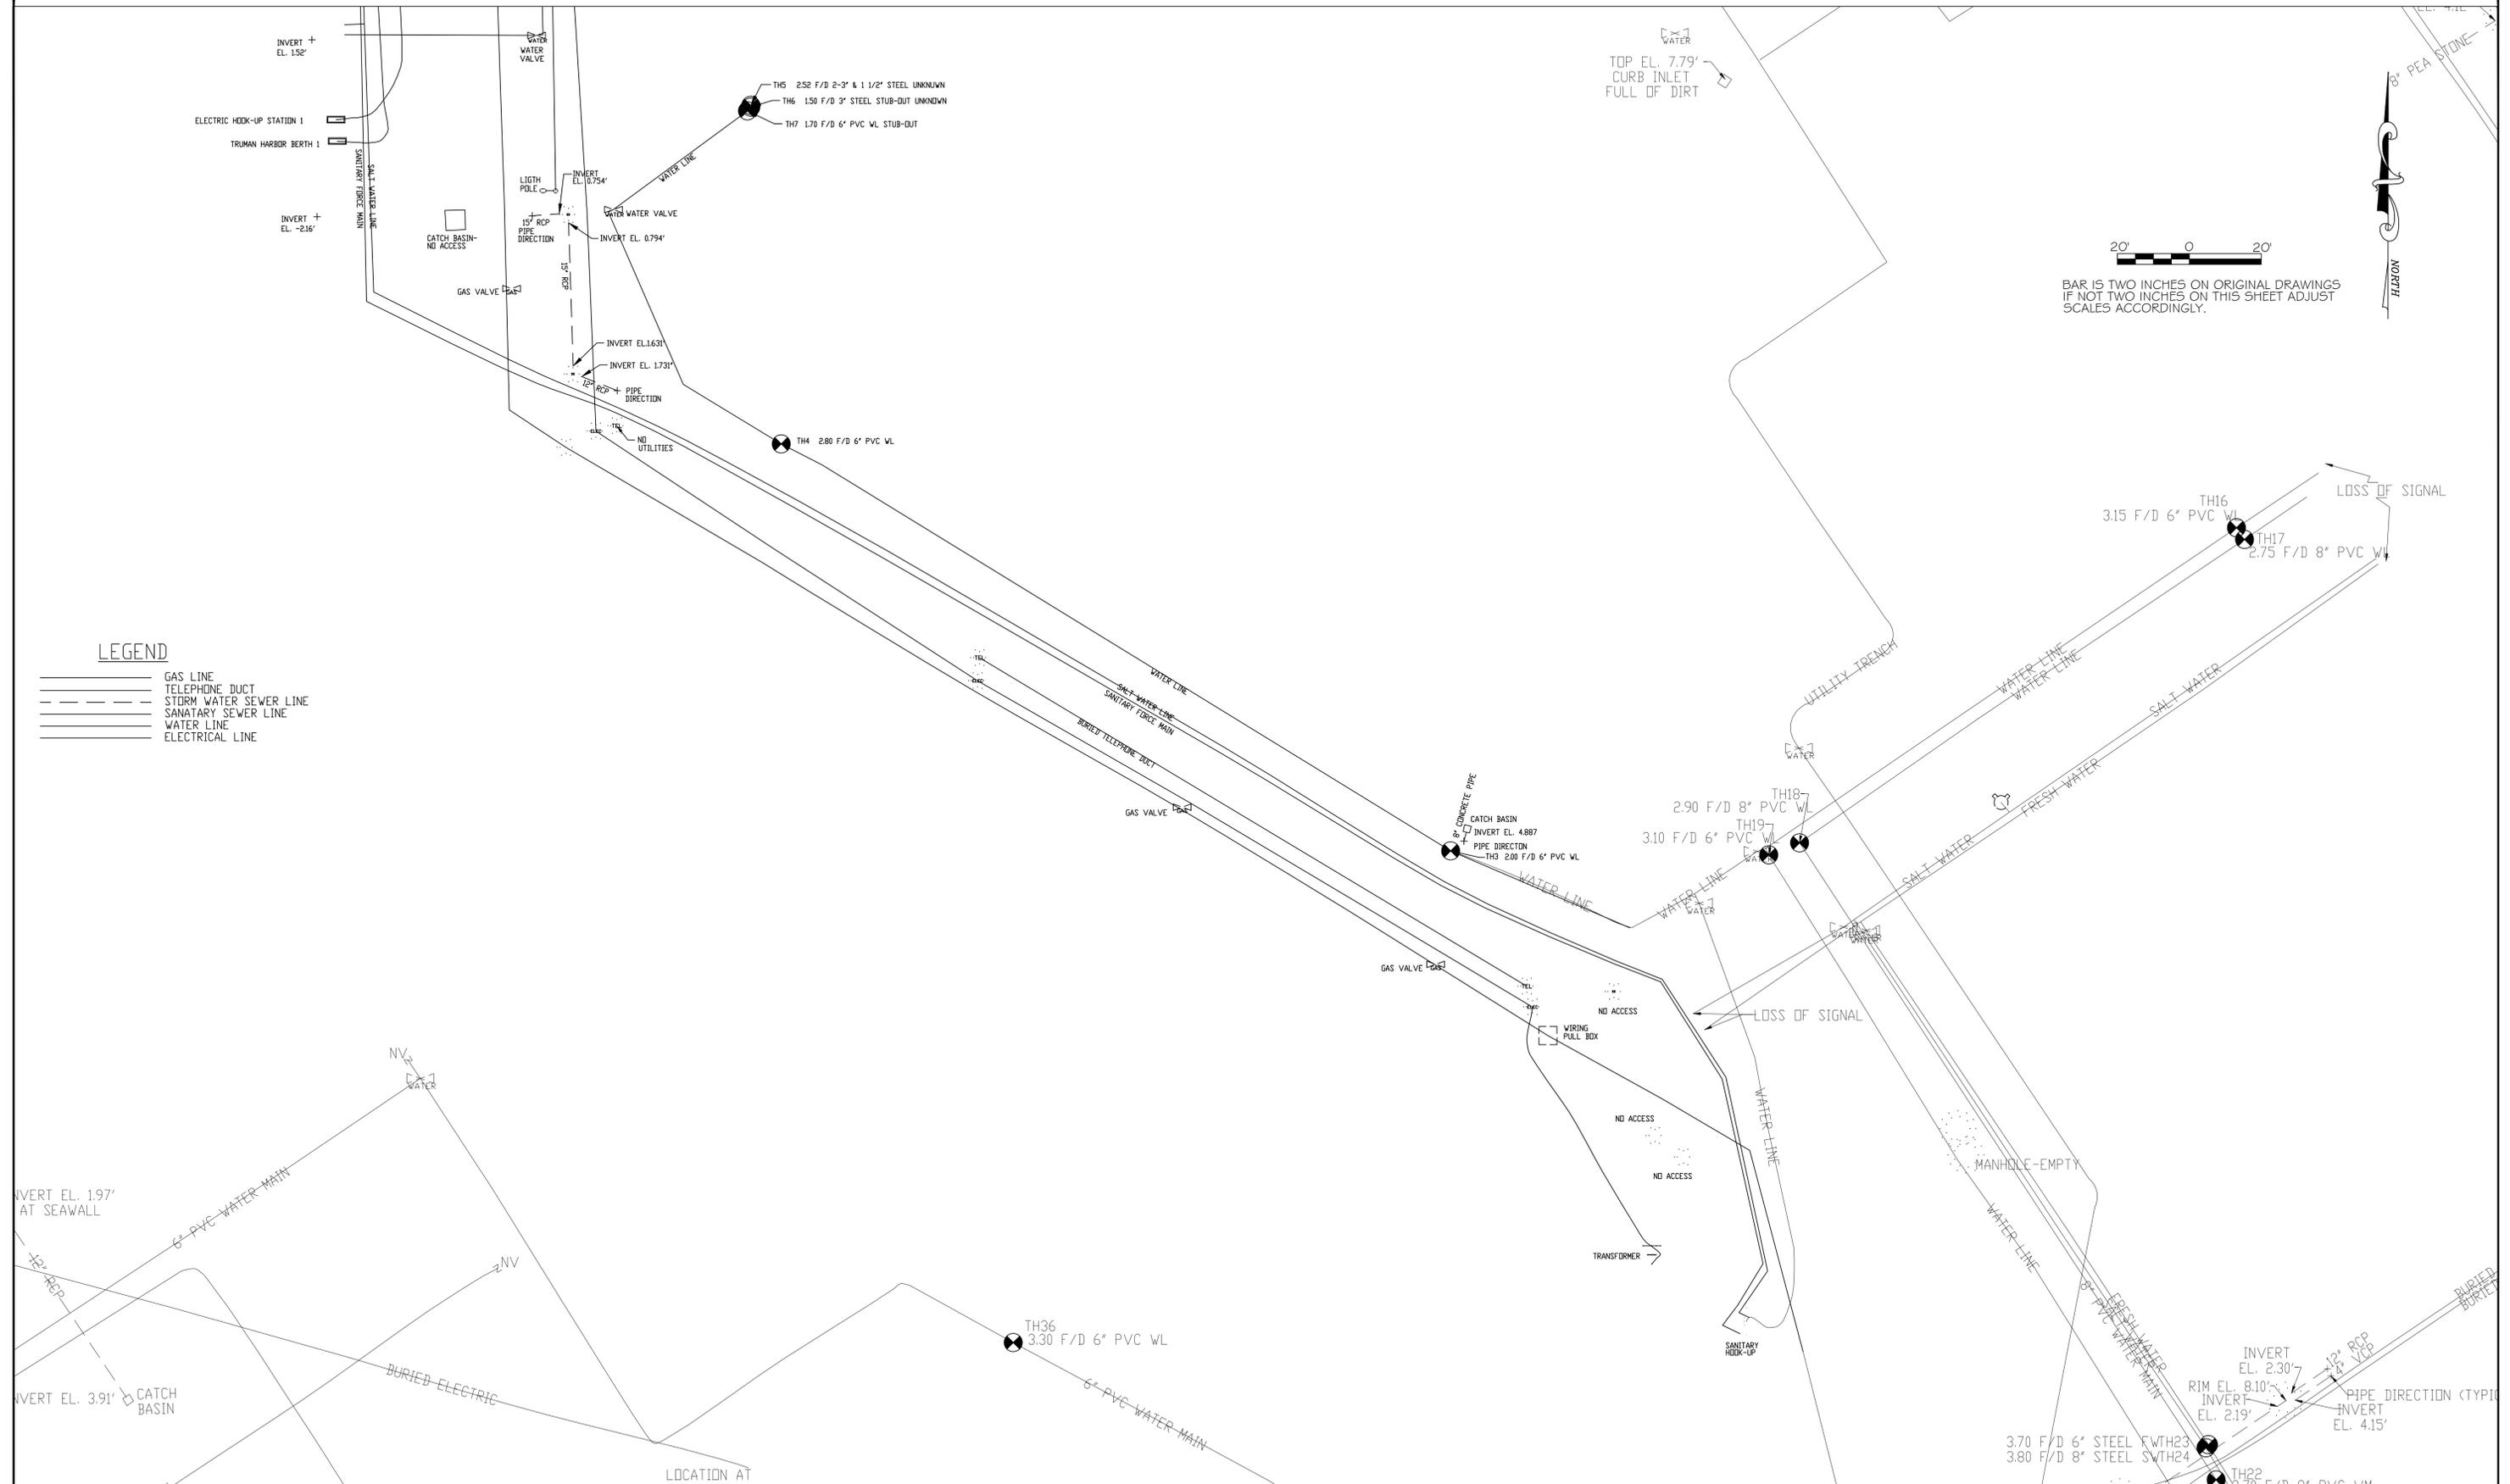

BAR IS TWO INCHES ON ORIGINAL DRAWINGS  
IF NOT TWO INCHES ON THIS SHEET ADJUST  
SCALES ACCORDINGLY.



**LEGEND**

- ===== GAS LINE
- TELEPHONE DUCT
- STORM WATER SEWER LINE
- SANITARY SEWER LINE
- WATER LINE
- ELECTRICAL LINE

INVERT EL. 1.97' AT SEAWALL  
INVERT EL. 3.91' CATCH BASIN  
12" RCP  
6" PVC WATER MAIN  
BURIED ELECTRIC

**P E & D , Inc.**  
Certificate of Authorization #8579  
**Perez Engineering & Development, Inc.**  
3210 FLAGLER AVENUE  
Key West, FL 33040  
ph: (305) 293-9440 • fax: (305) 296-0243

| No. | Revision/Issue | Date |
|-----|----------------|------|
|     |                |      |


|              |     |          |             |
|--------------|-----|----------|-------------|
| Designed By: | AEP | Project: | UTILITY.DWG |
| Checked By:  | AEP | Date:    | 1/23/03     |
| Drawn By:    | GKG | Scale:   | 1" = 20'    |



**City of Key West**

**East Quay Subsurface Utility Map**  
KEY WEST, FL  
SUBSURFACE UTILITY MAP

|   |            |
|---|------------|
| Allen E. Perez  | P.E.#51468 |
| NOT VALID FOR CONSTRUCTION UNLESS SIGNED AND SEALED IN THIS BLOCK |            |
| Sheet<br><b>C-6</b>   |            |

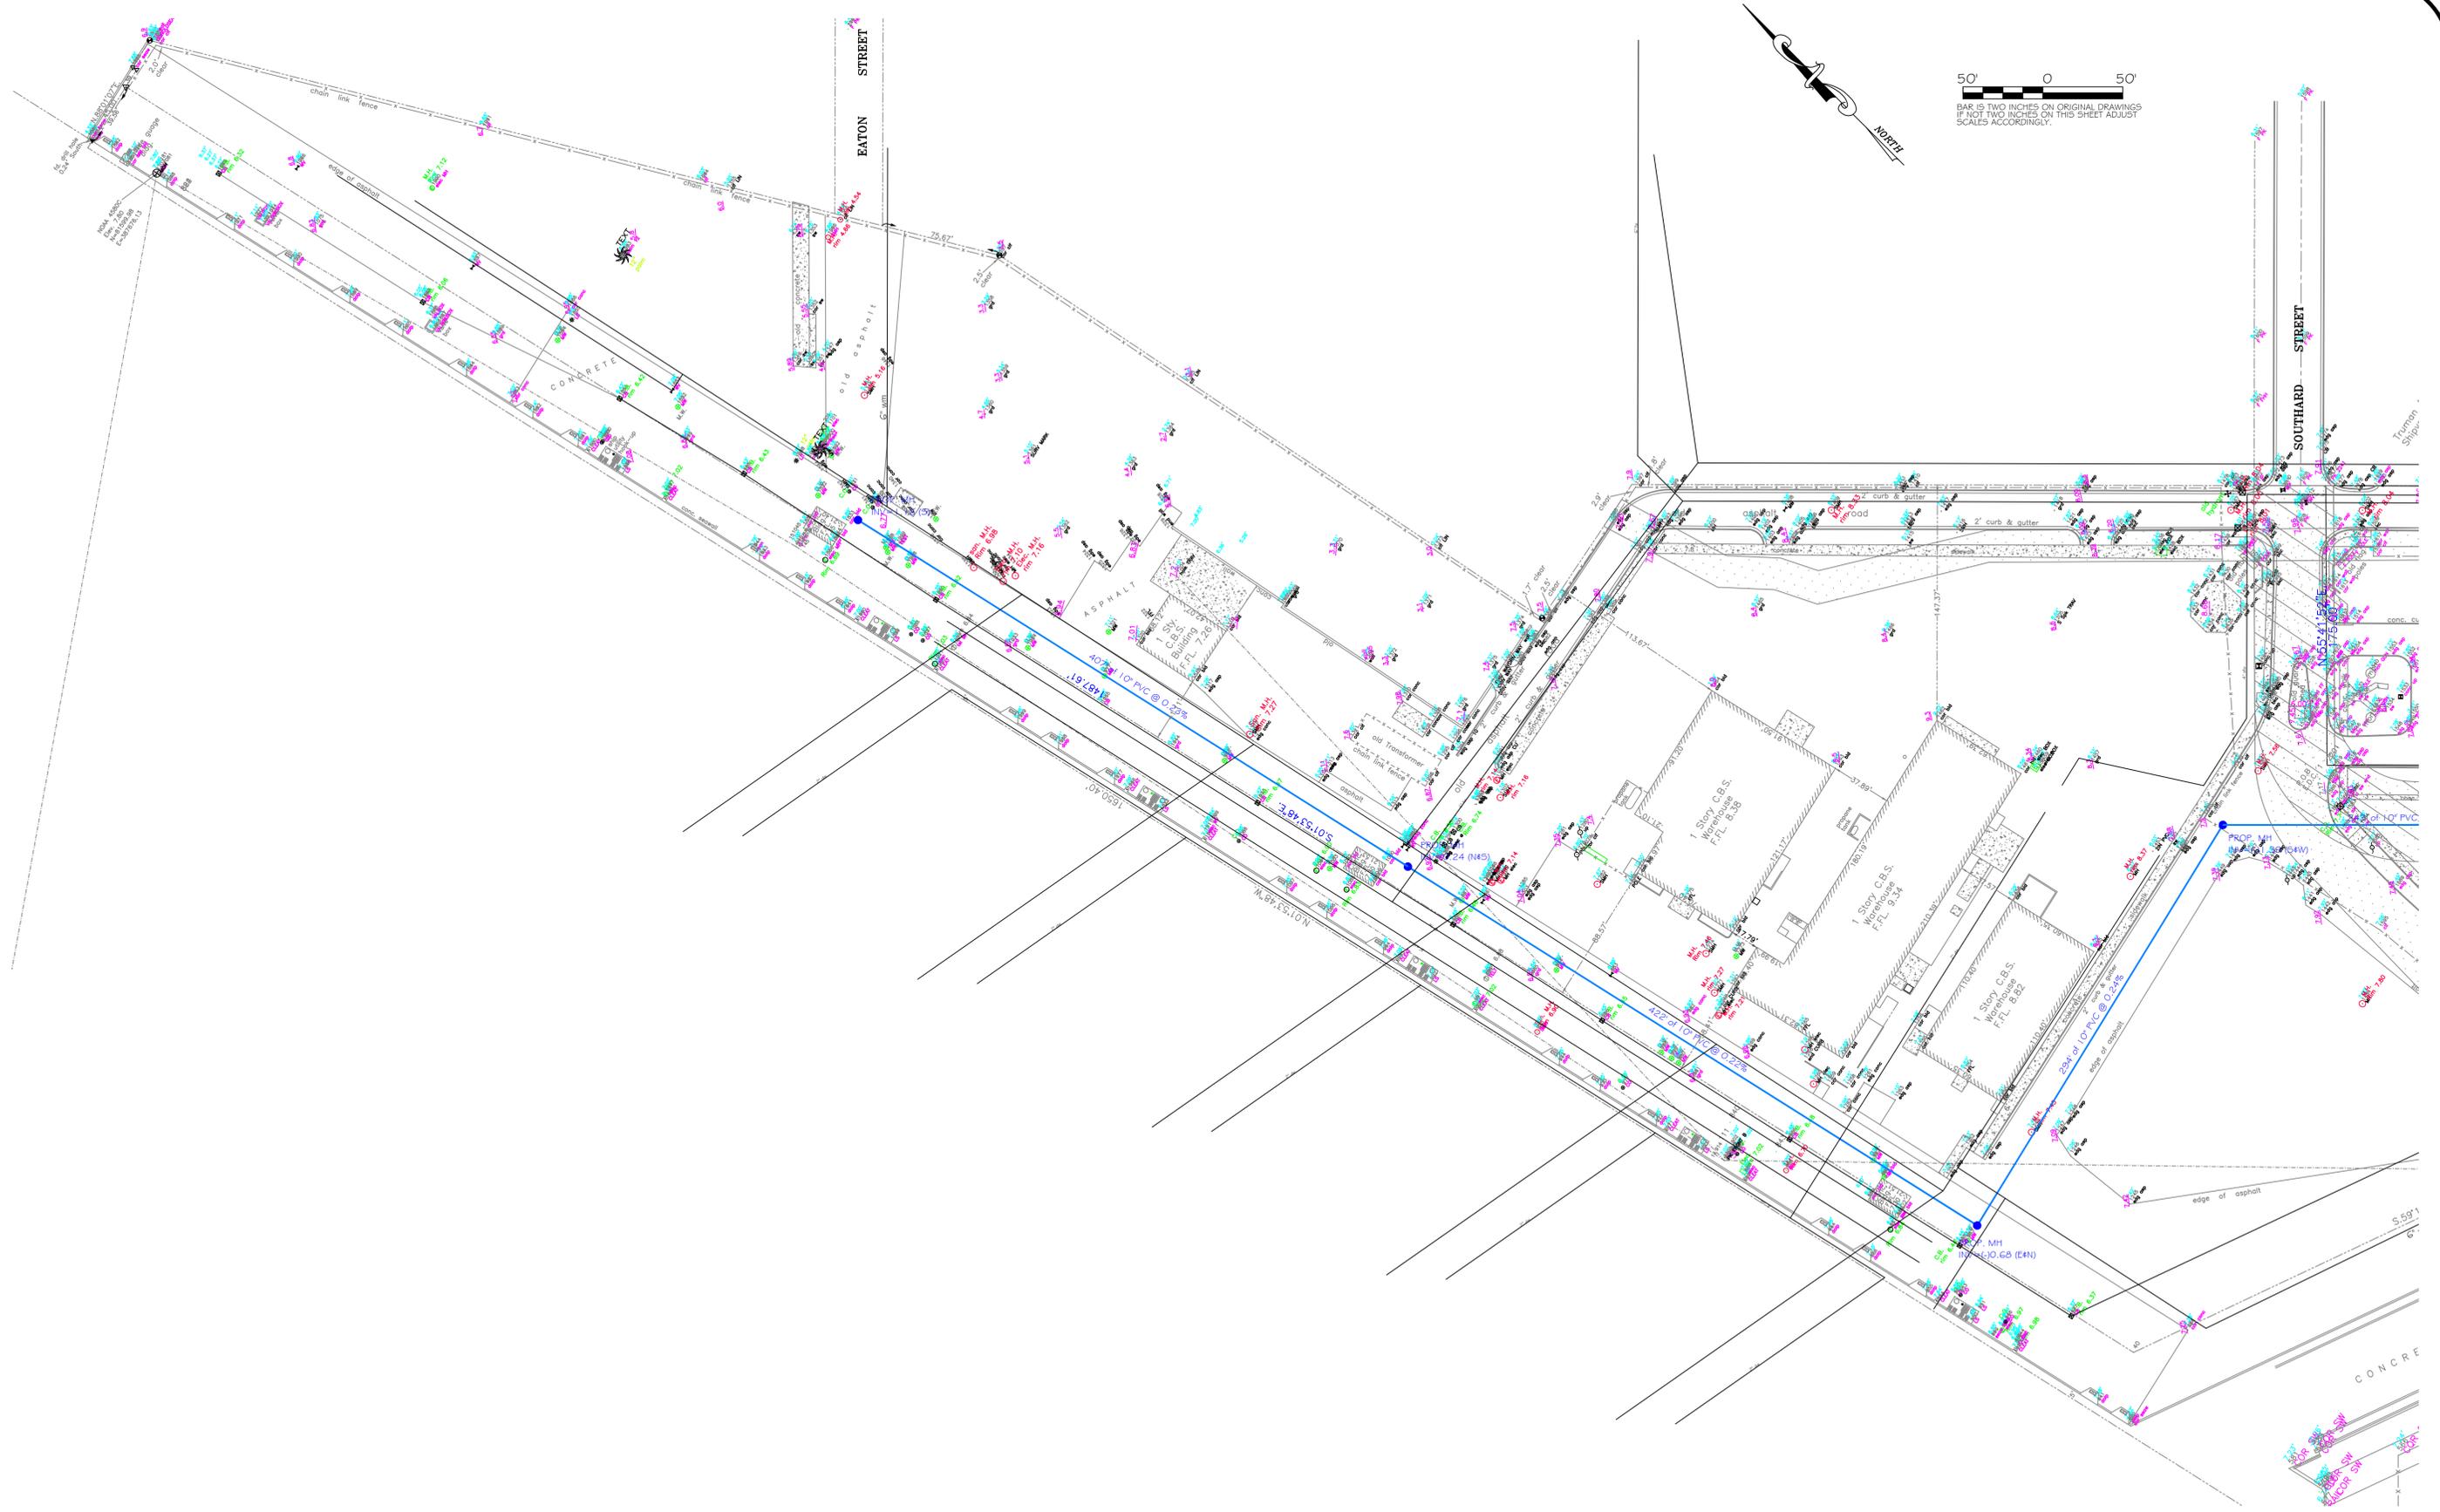

General Notes:

48 HOURS BEFORE DIGGING  
CALL TOLL FREE  
**1-800-432-4770**  
SUNSHINE STATE UNDERGROUND  
UTILITIES NOTIFICATION CENTER



**P E & D, Inc.**

Perez Engineering  
& Development, Inc.  
3210 FLAGLER AVENUE  
Key West, FL 33040  
ph: (305) 293-9440 \* fax: (305) 296-0243

| No. | Revision/Issue | Date |
|-----|----------------|------|
|     |                |      |
|     |                |      |
|     |                |      |


|              |          |          |          |
|--------------|----------|----------|----------|
| Designed By: | AEP      | Project: | C-1.DWG  |
| Checked By:  | RJM      | Date:    | 9/23/02  |
| Drawn By:    | K.I.C.D. | Scale:   | AS SHOWN |

**EAST QUAY**  
KEY WEST, FLORIDA  
**SITE PLAN**

ALLEN E. PEREZ P.E.#51458  
NOT VALID FOR CONSTRUCTION UNLESS  
SIGNED AND SEALED IN THIS BLOCK  
Sheet  
C-1



SCALE: **PLAN**  
HORIZ. - 1" = 20'

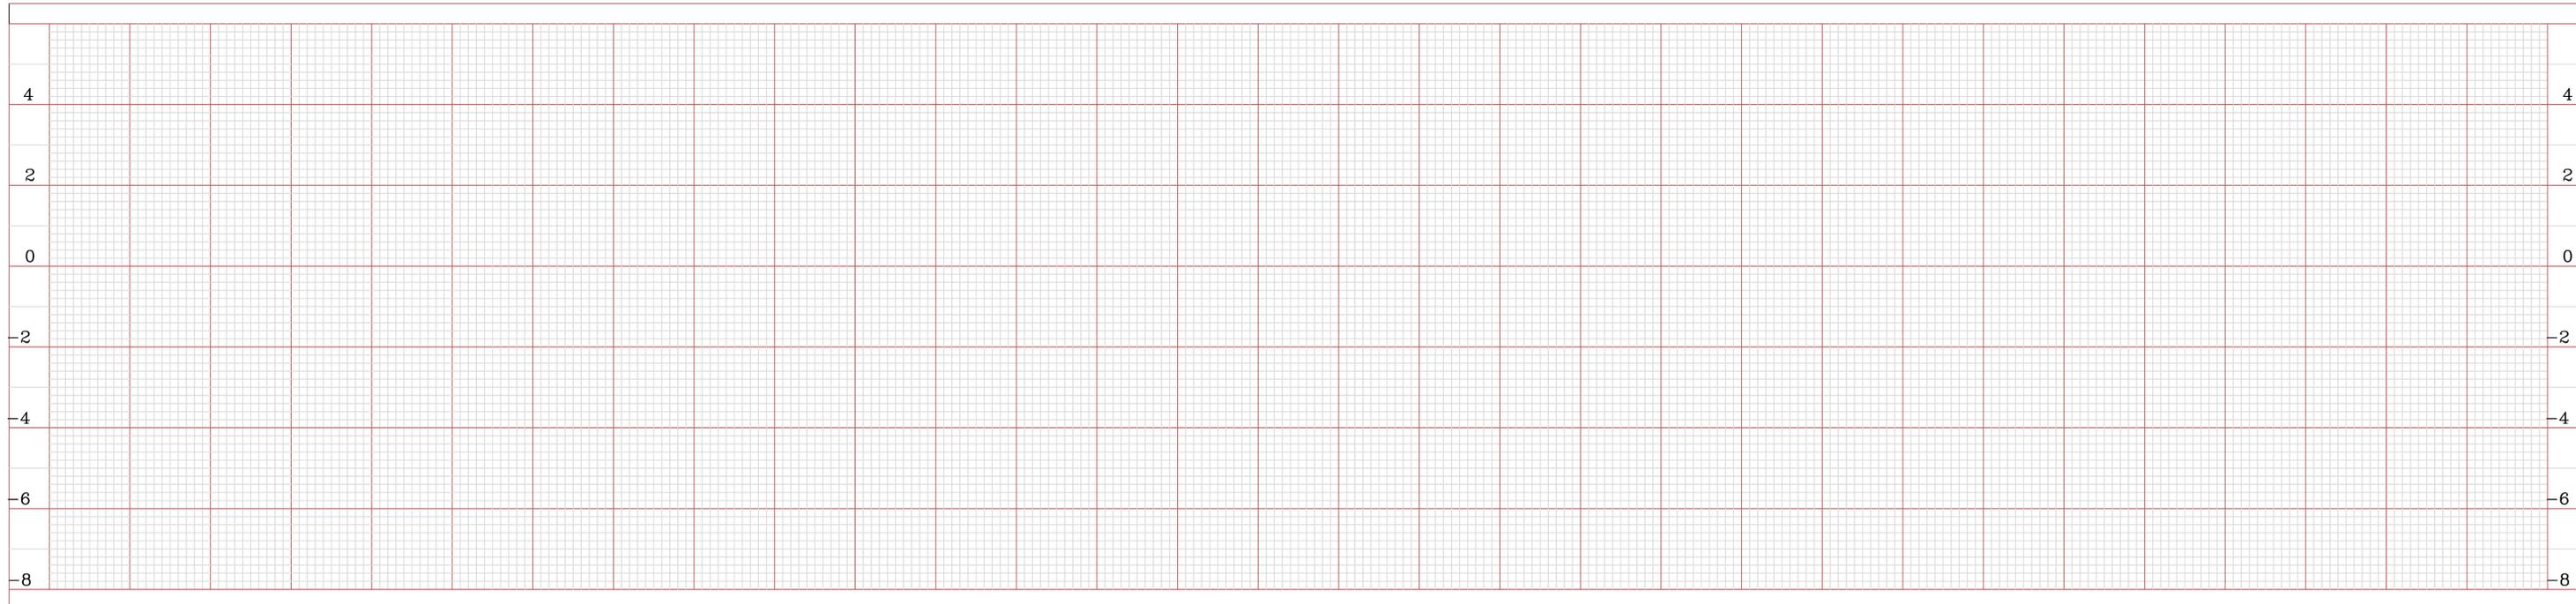

SCALE: **PROFILE**  
HORIZ. - 1" = 20'  
VERT. - 1" = 2'

48 HOURS BEFORE DIGGING  
SCALE: TOLL FREE  
**1-800-432-4770**  
VERT. - 1" = 2'  
SUNSHINE STATE UNDERGROUND  
UTILITIES NOTIFICATION CENTER

0 1"  
BAR IS ONE INCH ON ORIGINAL DRAWINGS  
IF NOT ONE INCH ON THIS SHEET ADJUST  
SCALES ACCORDINGLY

| DATE             | REVISIONS  | BY: |
|------------------|------------|-----|
| 2/23/00 10:39 AM | atonic.dwg |     |
|                  |            |     |
|                  |            |     |

**City of Key West**  
UTILITIES DEPARTMENT  
1400 Venetian Drive  
Key West, Florida 33040  
(305) 292-5600

| TITLE BLOCK INFORMATION |          | PROJECT NO. BR-0104 |       |
|-------------------------|----------|---------------------|-------|
| DESIGN:                 | AEP      | DRAWING DATE:       | 5/01  |
| DRAWN BY:               | ESA      | DRAWING NO.:        | X.dwg |
| CHECKED:                | RTE      | CITY ENGINEER:      |       |
| SCALE:                  | AS NOTED | DATE:               |       |
| PLAN & PROFILE          |          | SHEET:              | 1     |